


APPENDIX H

DRAWINGS




REFERENCE DRAWINGS		REVISIONS				DESIGNED:	D VAN COLLER	PROJECT ENGINEER:	P LE ROUX	MOKOLO CROCODILE Consultants TCTA A new word for water	MOKOLO CROCODILE WATER AUGMENTATION PROJECT (MCWAP)			
DRG. No.	TITLE	REV No.	DATE	DESCRIPTION	APPR.	DRAWN:	D VAN COLLER	TCTA:			VLEIPOORT ABSTRACTION WORKS			
		A	28/01/11	FOR INFORMATION	PLR	CHECKED:	J MULDER				GENERAL LAYOUT			
						CHIEF DESIGNER:		SCALE:	1:1000					
						SCALE 1 : 1000 0 5 10 15 20 25 50								

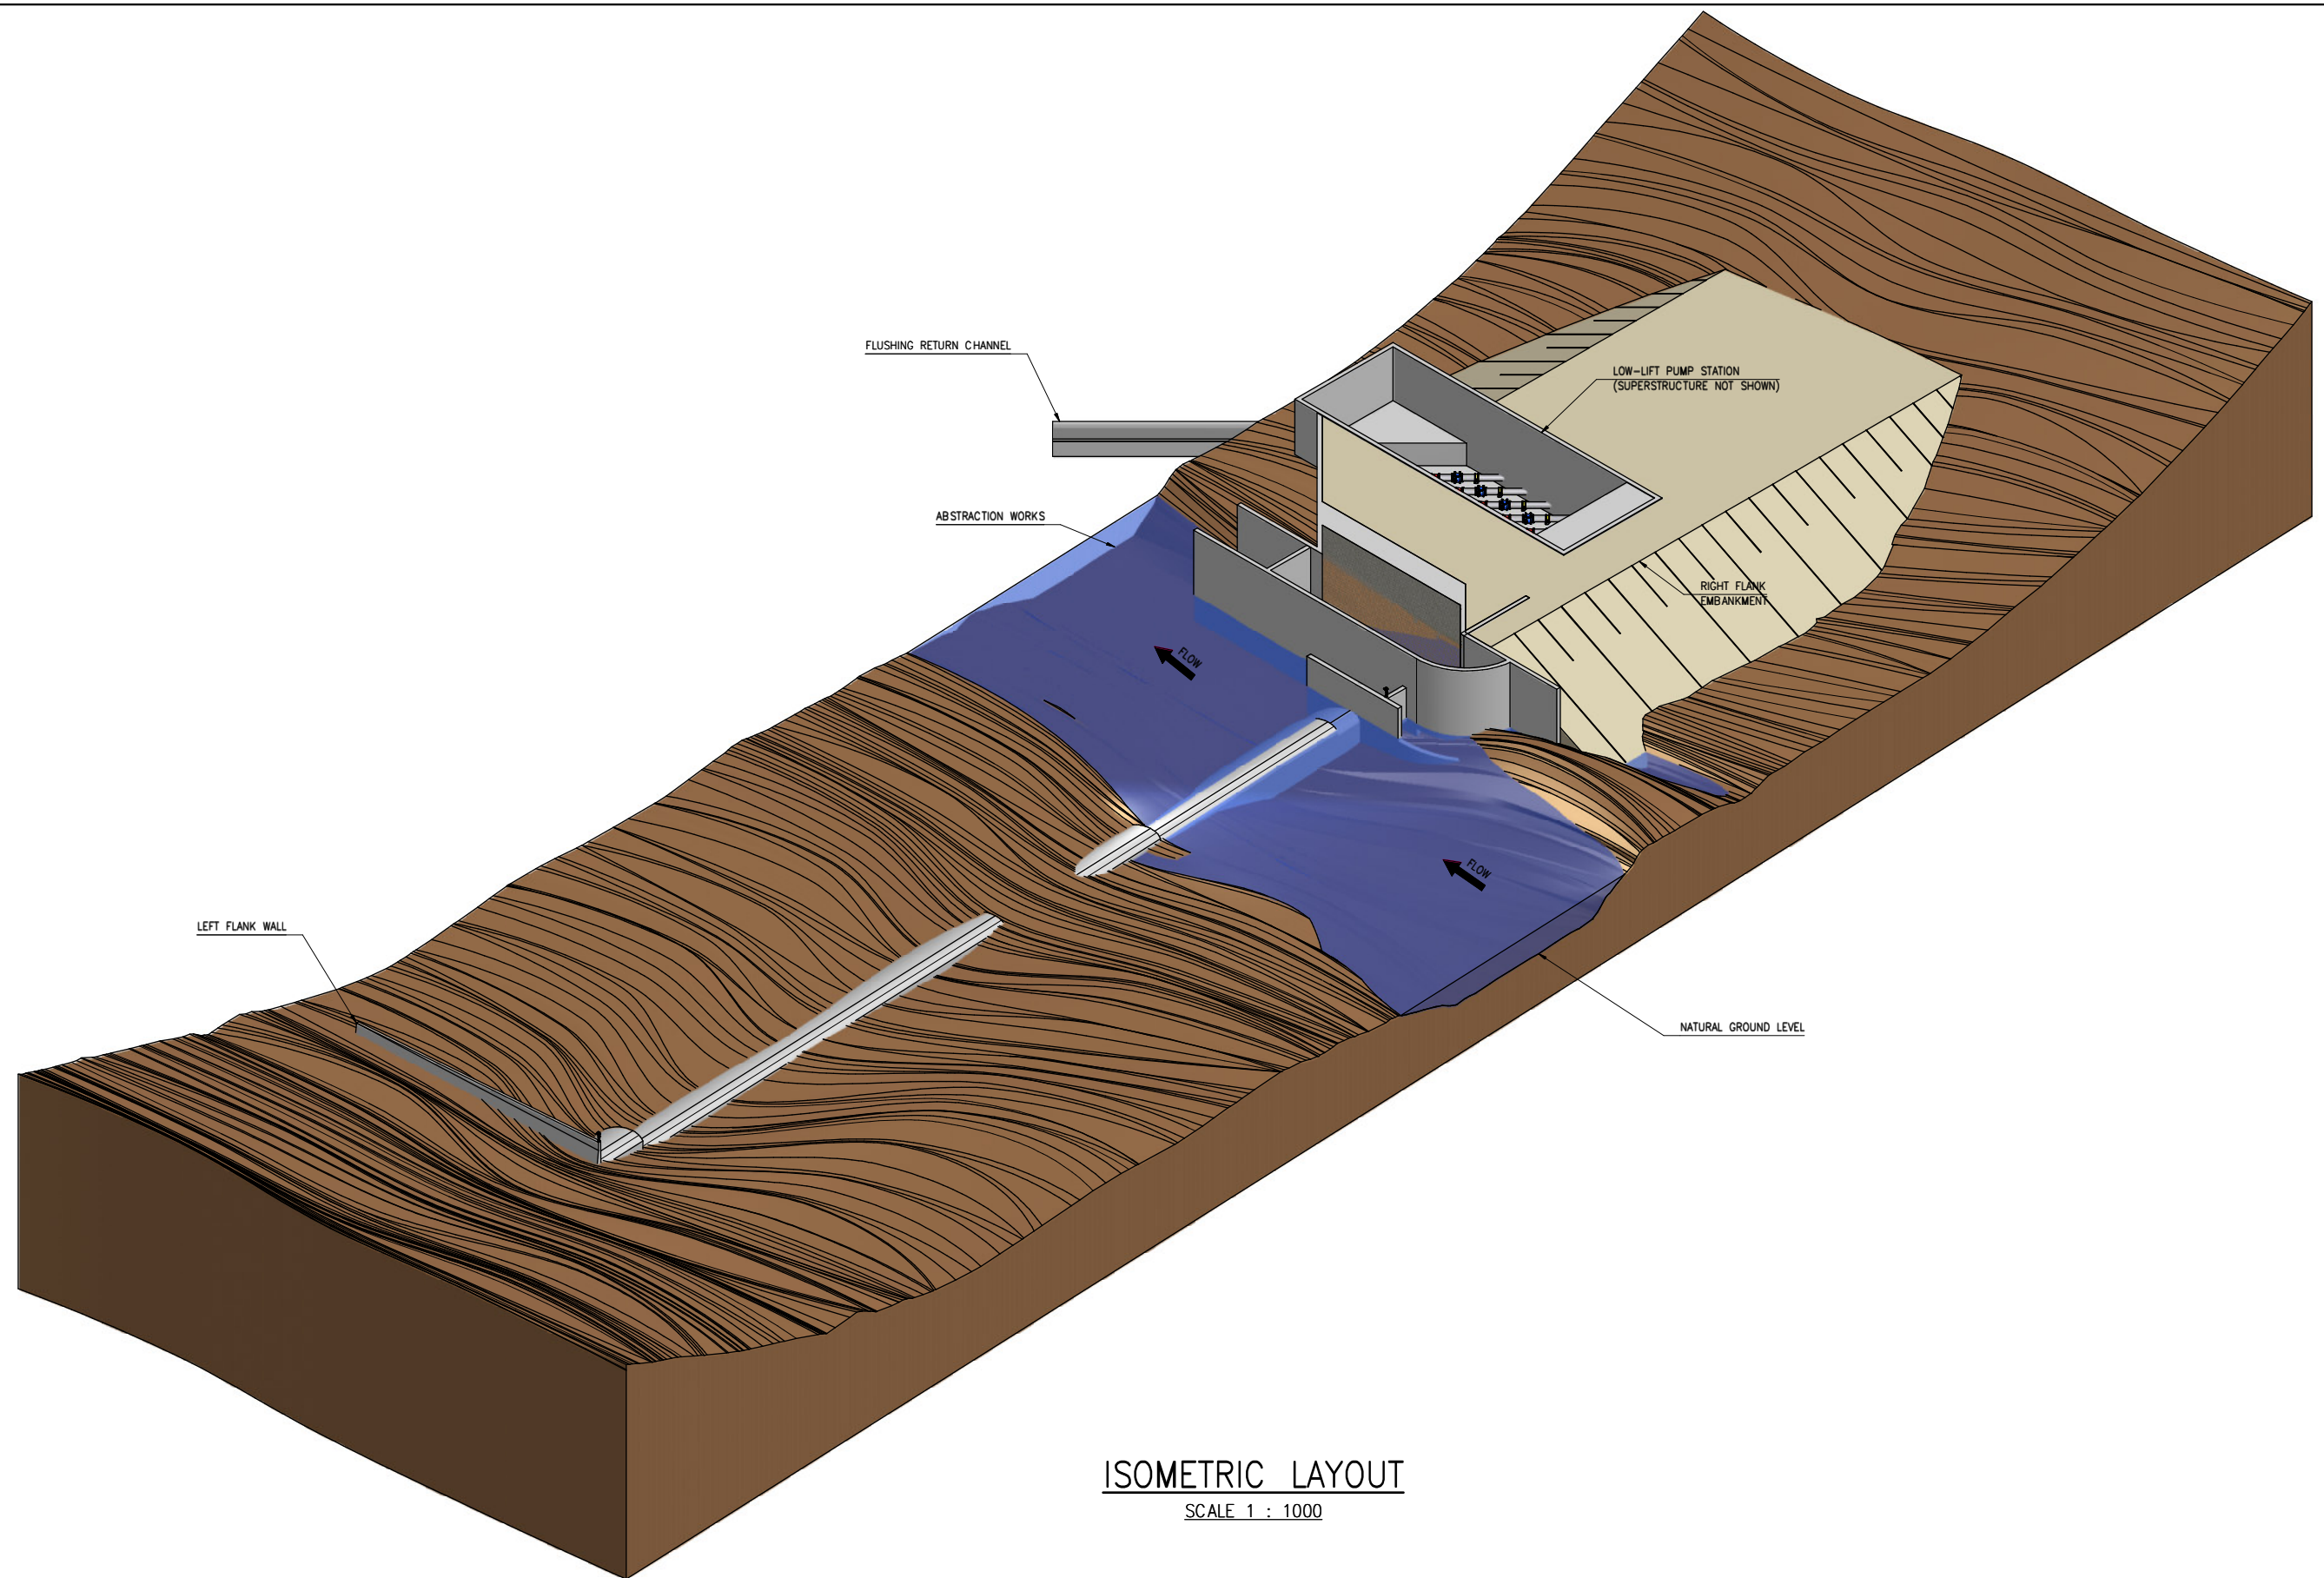


ISOMETRIC LAYOUT
SCALE 1 : 1000

REFERENCE DRAWINGS		REVISIONS				DESIGNED:	D VAN COLLER	PROJECT ENGINEER:	P LE ROUX	MOKOLO CROCODILE Consultants TCTA A new word for water	MOKOLO CROCODILE WATER AUGMENTATION PROJECT (MCWAP)		
DRG. No.	TITLE	REV No.	DATE	DESCRIPTION	APPR.	DRAWN:	D VAN COLLER	TCTA:			VLEEPOORT ABSTRACTION WORKS		
		A	28/01/11	FOR INFORMATION	PLR	CHECKED:	J MULDER				GENERAL LAYOUT		
						CHIEF DESIGNER:		SCALE:	1:1 000		ISOMETRIC VIEW		
						SCALE 1 : 1 000			051015202550		A3 DWAF		
										DRG. No.		DRAWING NUMBER 2B-C5-001	REV No. A

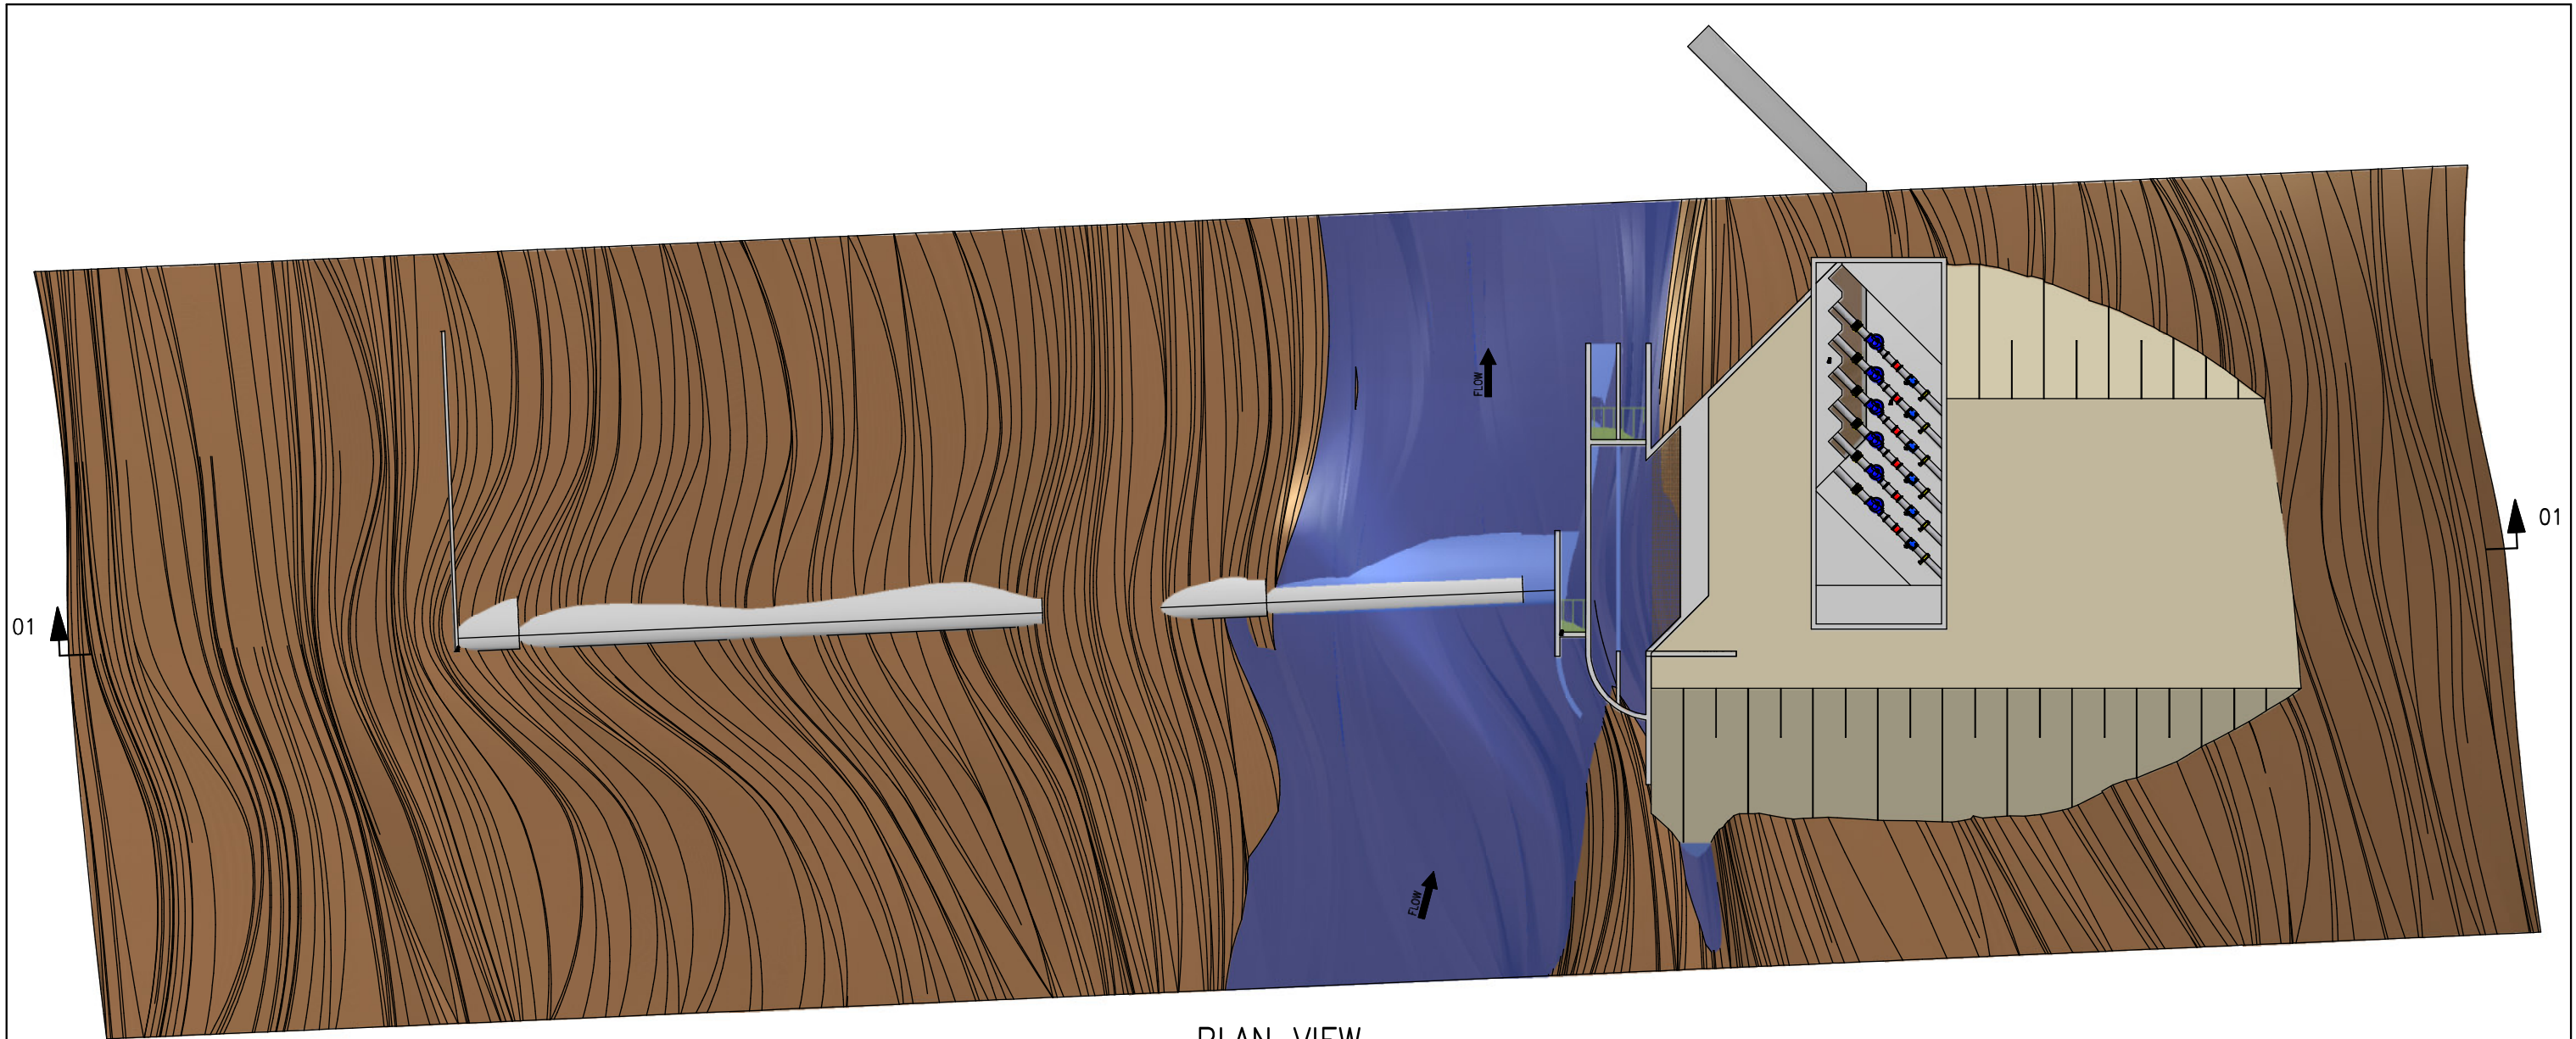


PLAN VIEW
SCALE 1 : 1000

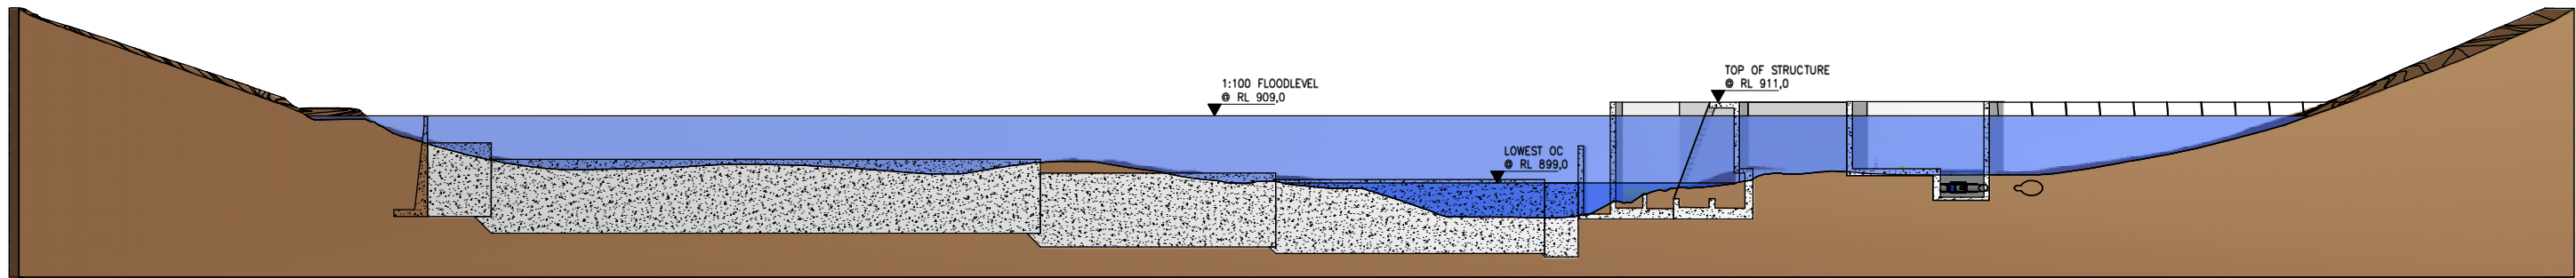


SECTION 01-01
SCALE 1 : 1000


REFERENCE DRAWINGS		REVISIONS				DESIGNED:	D VAN COLLER	PROJECT ENGINEER:	P LE ROUX		MOKOLO CROCODILE WATER AUGMENTATION PROJECT (MCWAP)			
DRG. No.	TITLE	REV No.	DATE	DESCRIPTION	APPR.	DRAWN:	D VAN COLLER	TCTA:			VLIEPOORT ABSTRACTION WORKS			
						CHECKED:	J MULDER				GENERAL LAYOUT			
						CHIEF DESIGNER:		SCALE:	1:1000		PLAN AND SECTION			
						SCALE 1 : 1 000 					A3	DWAF DRG. No.	DRAWING NUMBER 2B-C5-002	REV No. A

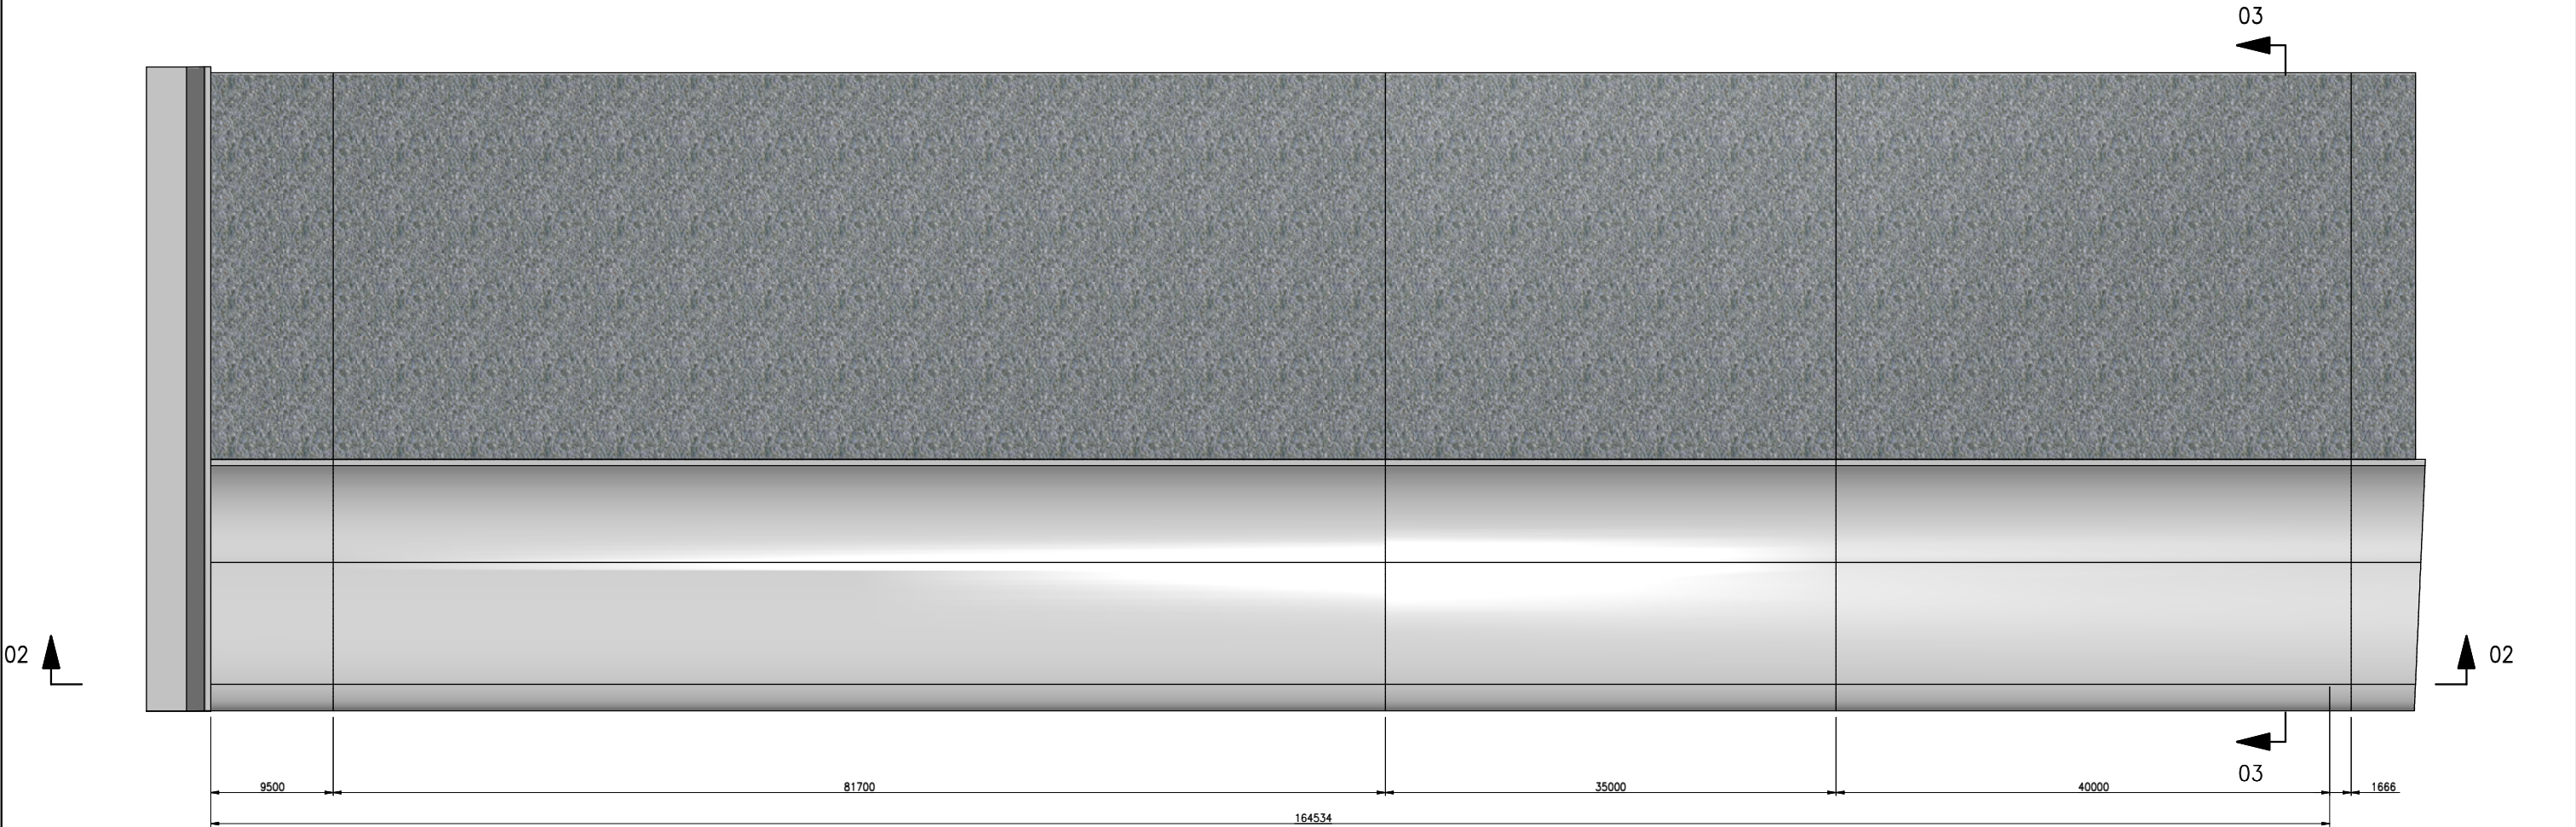


WEIR LAYOUT PLAN
SCALE 1 : 500

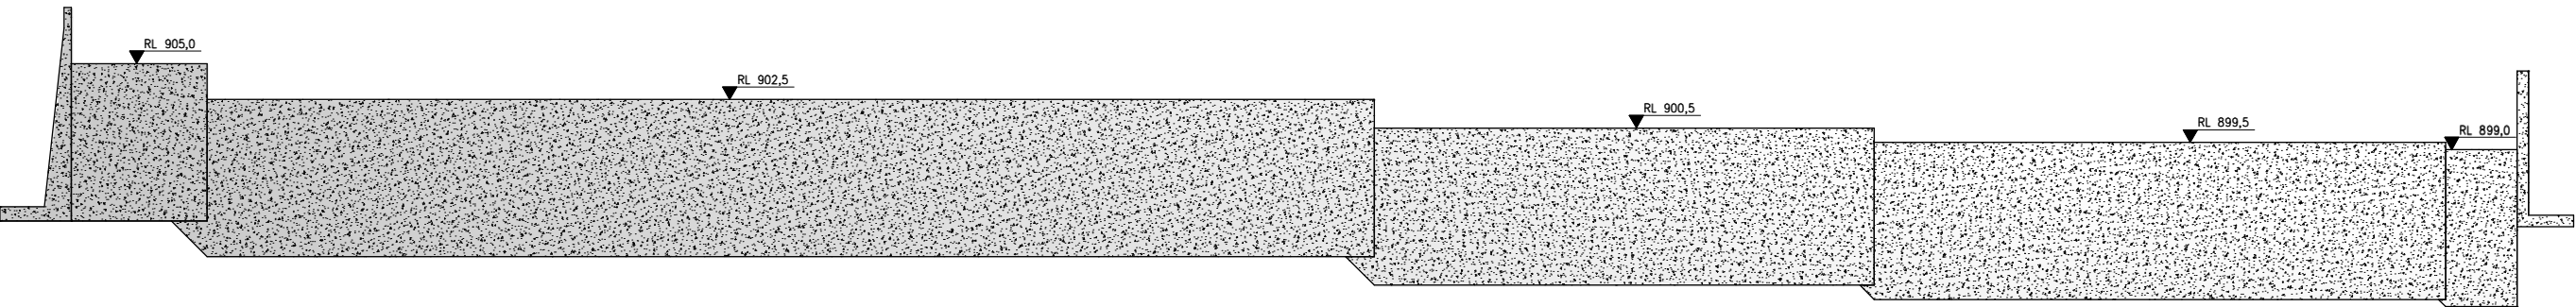



WEIR LONG SECTION 02-02
SCALE 1 : 500

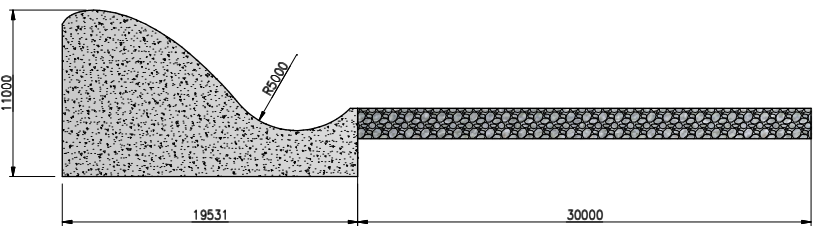


WEIR CROSS SECTION 03-03
SCALE 1 : 500

 REFERENCE DRAWINGS		REVISIONS				DESIGNED:	D VAN COLLER	PROJECT ENGINEER:	P LE ROUX		MOKOLO CROCODILE WATER AUGMENTATION PROJECT (MCWAP)				
DRG. No.	TITLE	REV No.	DATE	DESCRIPTION	APPR.	DRAWN:	D VAN COLLER	TCTA:			VLIEEPOORT ABSTRACTION WORKS				
		A	28/01/11	FOR INFORMATION	PLR	CHECKED:	J MULDER				ABSTRACTION WEIR				
						CHIEF DESIGNER:		SCALE:	1:500		LAYOUT AND SECTIONS				
						SCALE 1 : 500									
										A3	DWAF DRG. No.	DRAWING NUMBER 2B-C5-003	REV No. A		

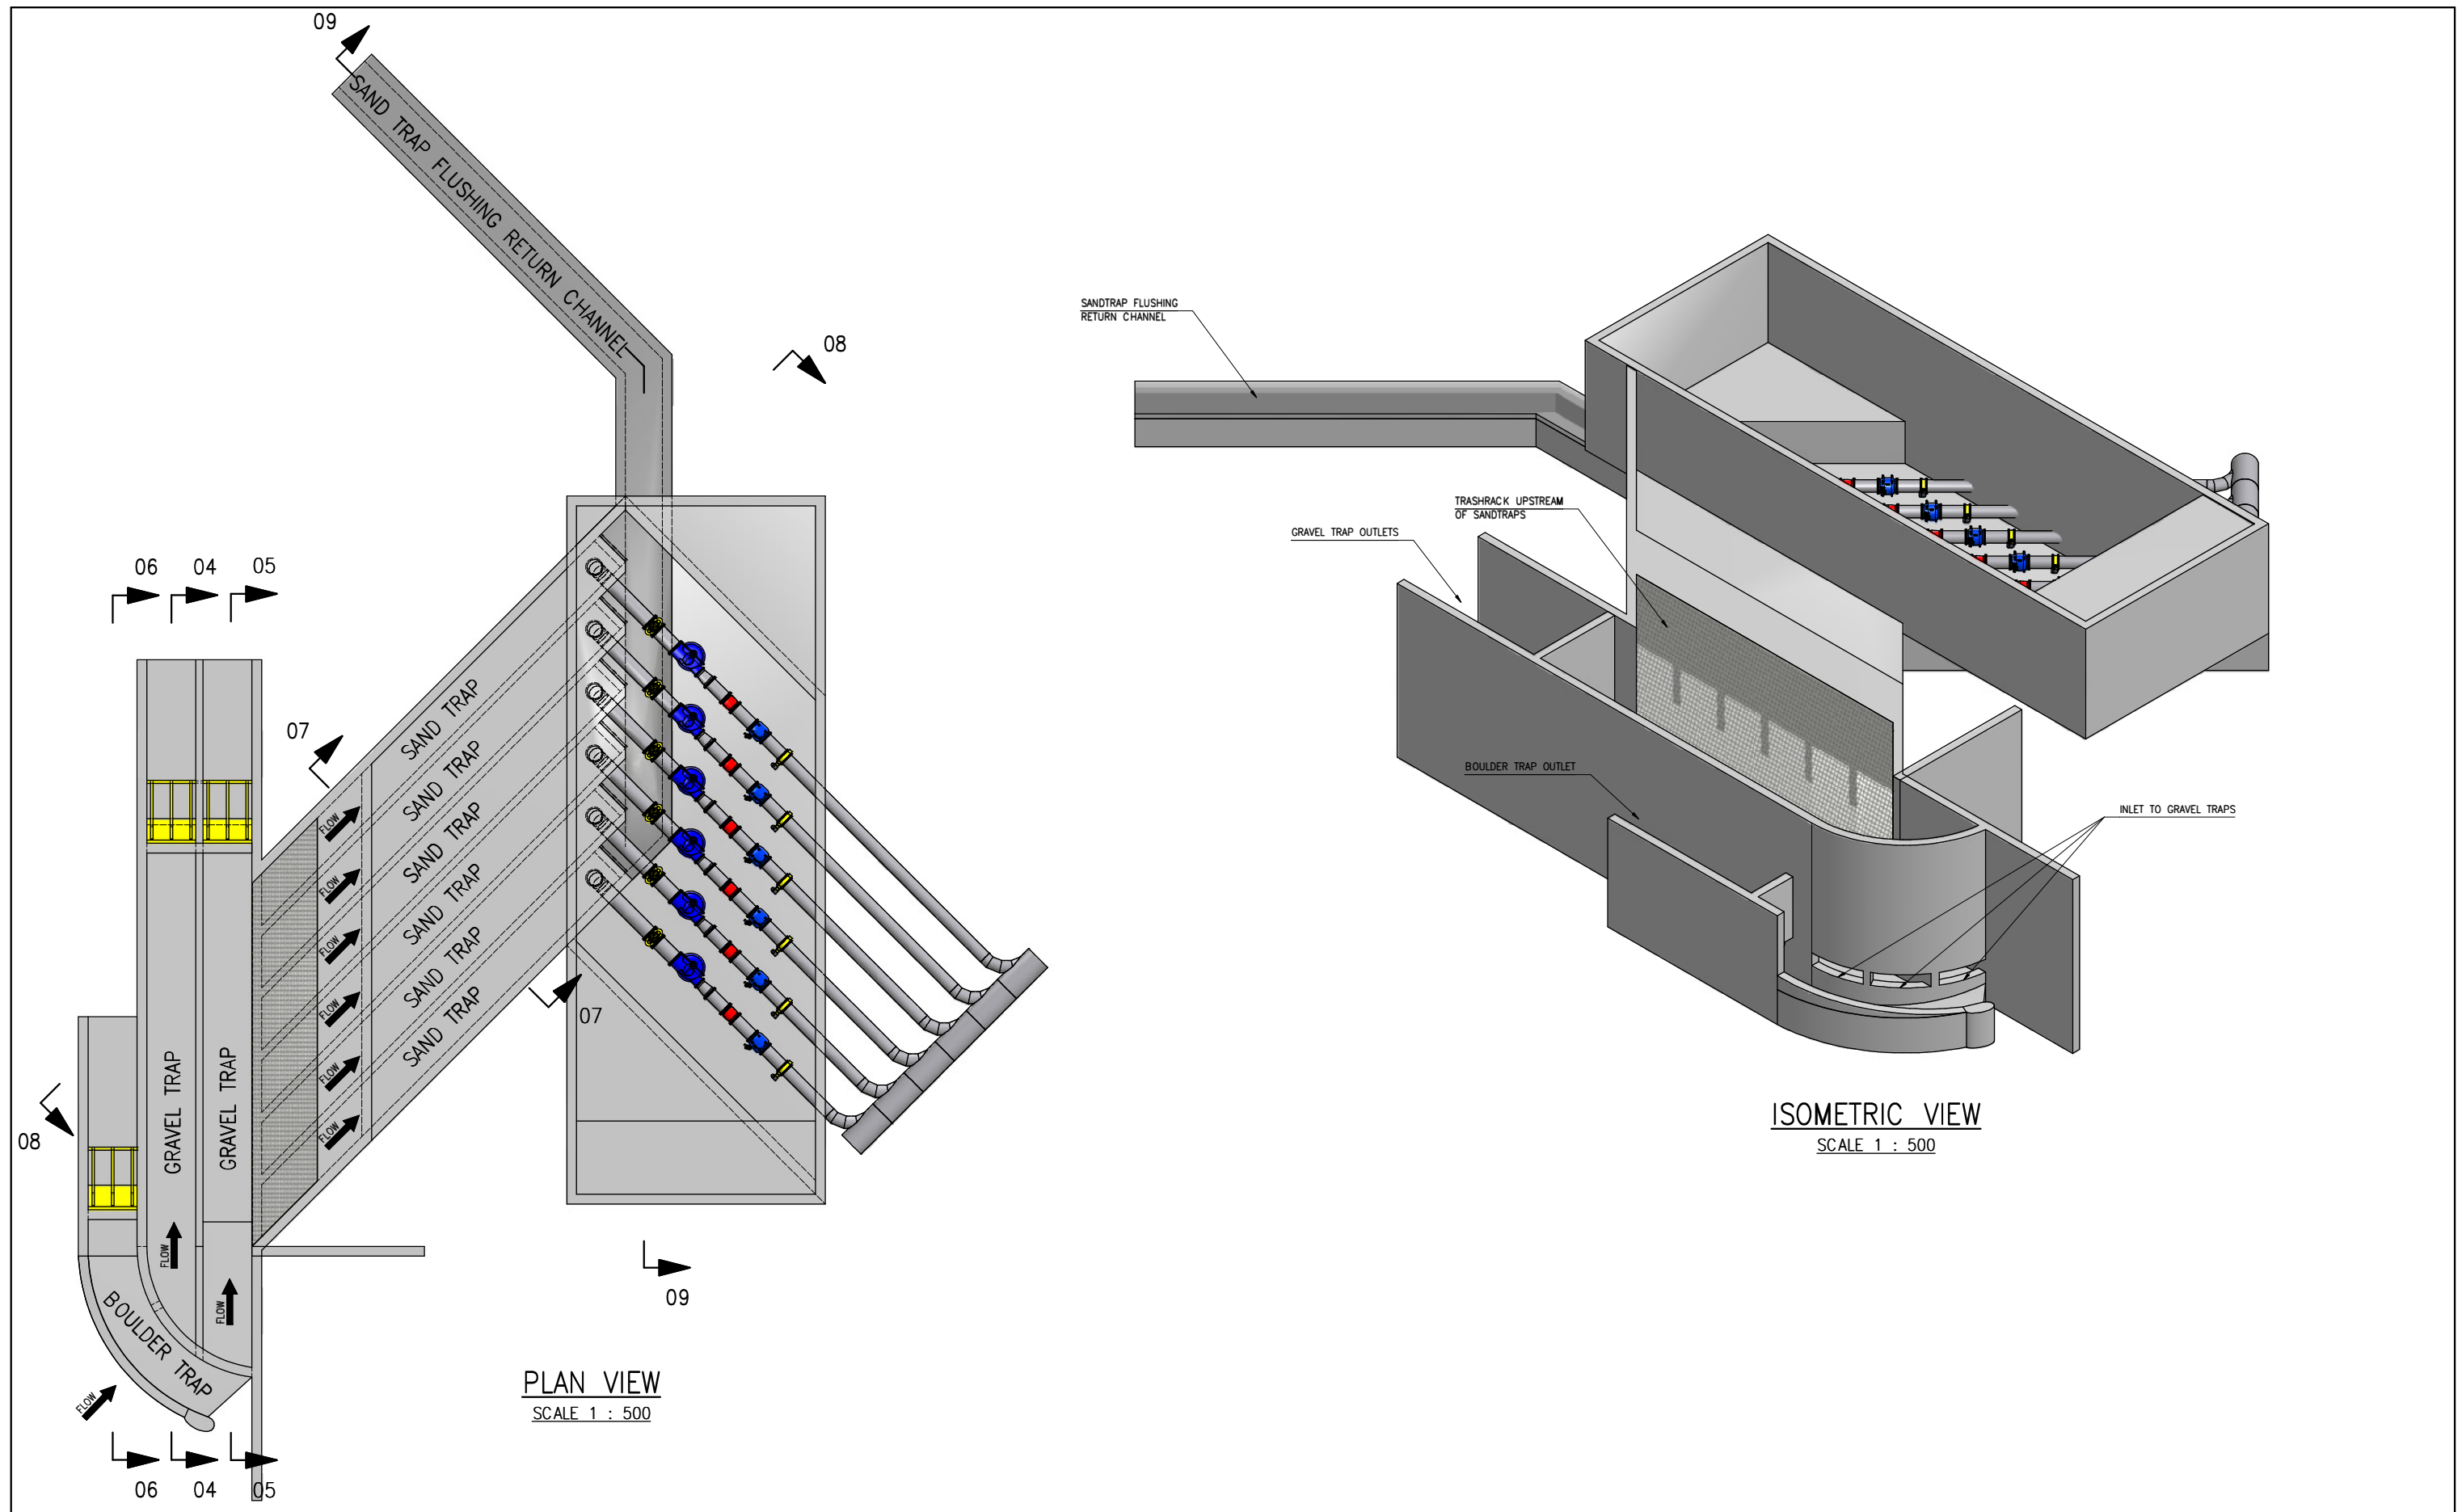


 REFERENCE DRAWINGS		REVISIONS				DESIGNED:	D VAN COLLER	PROJECT ENGINEER:	P LE ROUX		MOKOLO CROCODILE WATER AUGMENTATION PROJECT (MCWAP)			
DRG. No.	TITLE	REV No.	DATE	DESCRIPTION	APPR.	DRAWN:	D VAN COLLER	TCTA:			VLIEPOORT ABSTRACTION WORKS			
		A	28/01/11	FOR INFORMATION	PLR	CHECKED:	J MULDER				ABSTRACTION WORKS			
						CHIEF DESIGNER:		SCALE:	1:500		LAYOUT AND ISOMETRIC VIEW			
						SCALE 1 : 500								
											A3	DWAF DRG. No.	DRAWING NUMBER 2B-C5-004	REV No. A

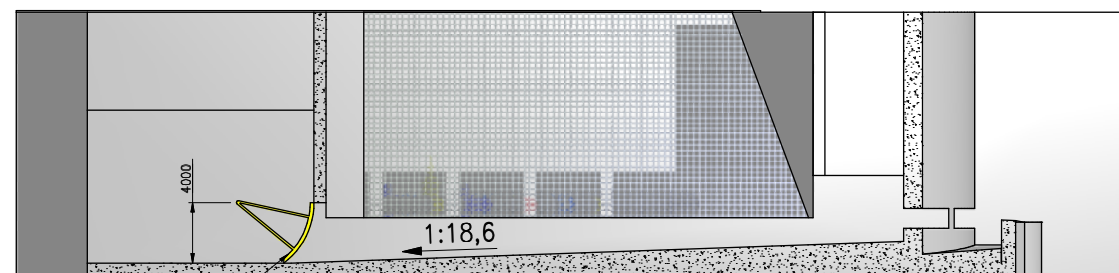


SECTION 04-04
THROUGH GRAVEL TRAP 1

SCALE 1 : 500

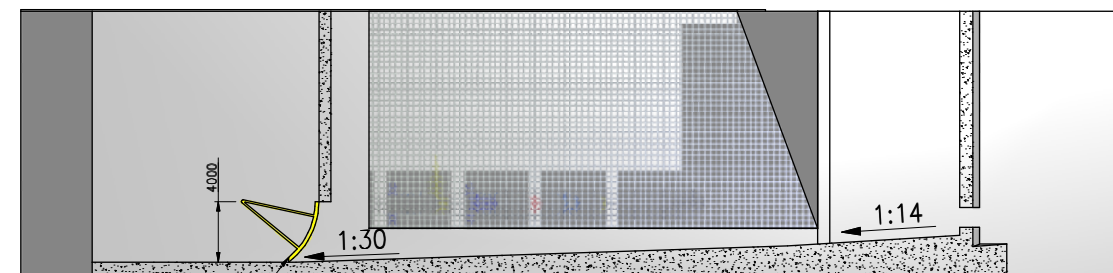


SECTION 05-05
THROUGH GRAVEL TRAP 2

SCALE 1 : 500

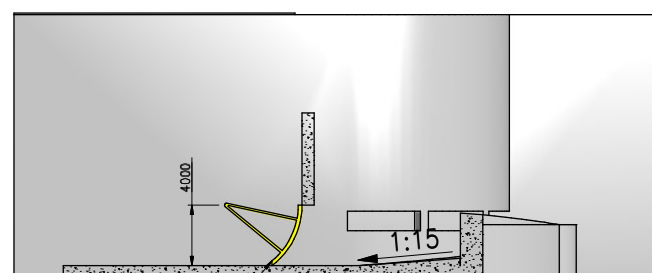


SECTION 06-06
THROUGH BOULDER TRAP

SCALE 1 : 500

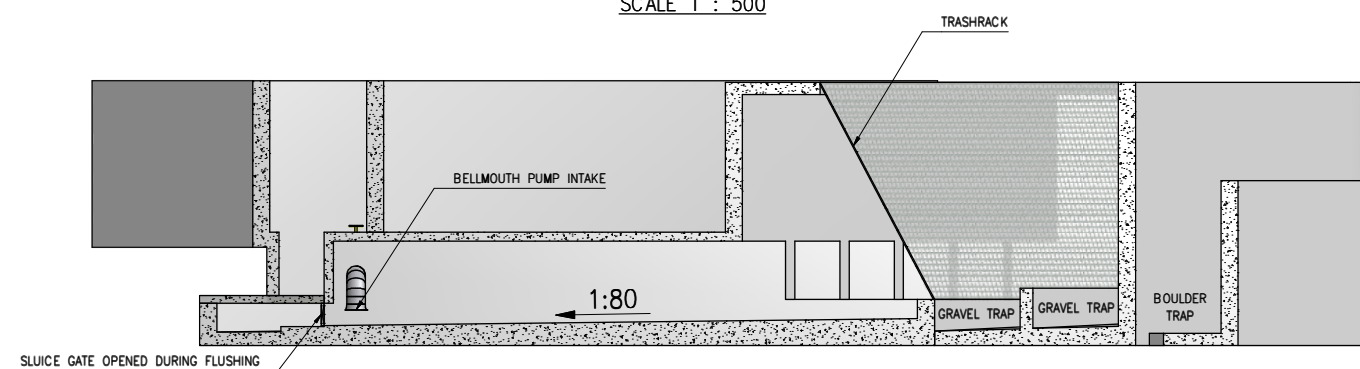


SECTION 08-08
THROUGH SAND TRAP CHANNEL

SCALE 1 : 500

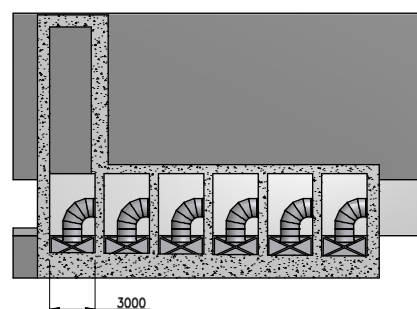

SECTION 07-07
ACROSS SAND TRAP CHANNELS


SCALE 1 : 500

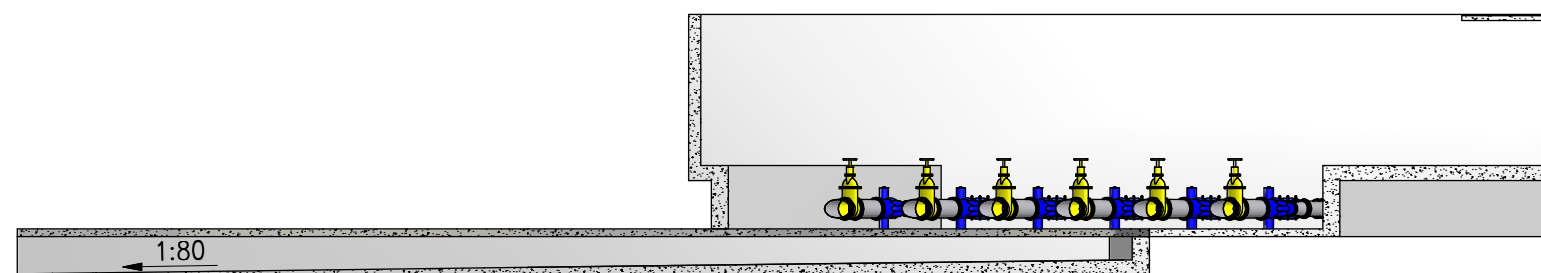

SECTION 09-09
THROUGH FLUSHING CHANNEL


SCALE 1 : 500


REFERENCE DRAWINGS		REVISIONS				DESIGNED:	D VAN COLLER	PROJECT ENGINEER:	P LE ROUX		MOKOLO CROCODILE WATER AUGMENTATION PROJECT (MCWAP)							
DRG. No.	TITLE	REV No.	DATE	DESCRIPTION	APPR.	DRAWN:	D VAN COLLER	TCTA:			VLIEEPOORT ABSTRACTION WORKS							
		A	28/01/11	FOR INFORMATION	PLR	CHECKED:	J MULDER				ABSTRACTION WORKS							
						CHIEF DESIGNER:		SCALE:	1:500		SECTIONS							
						SCALE 1 : 500						A3		DWAF		DRAWING	2B-C5-005	REV N
												DRG. No.			NUMBER		A	

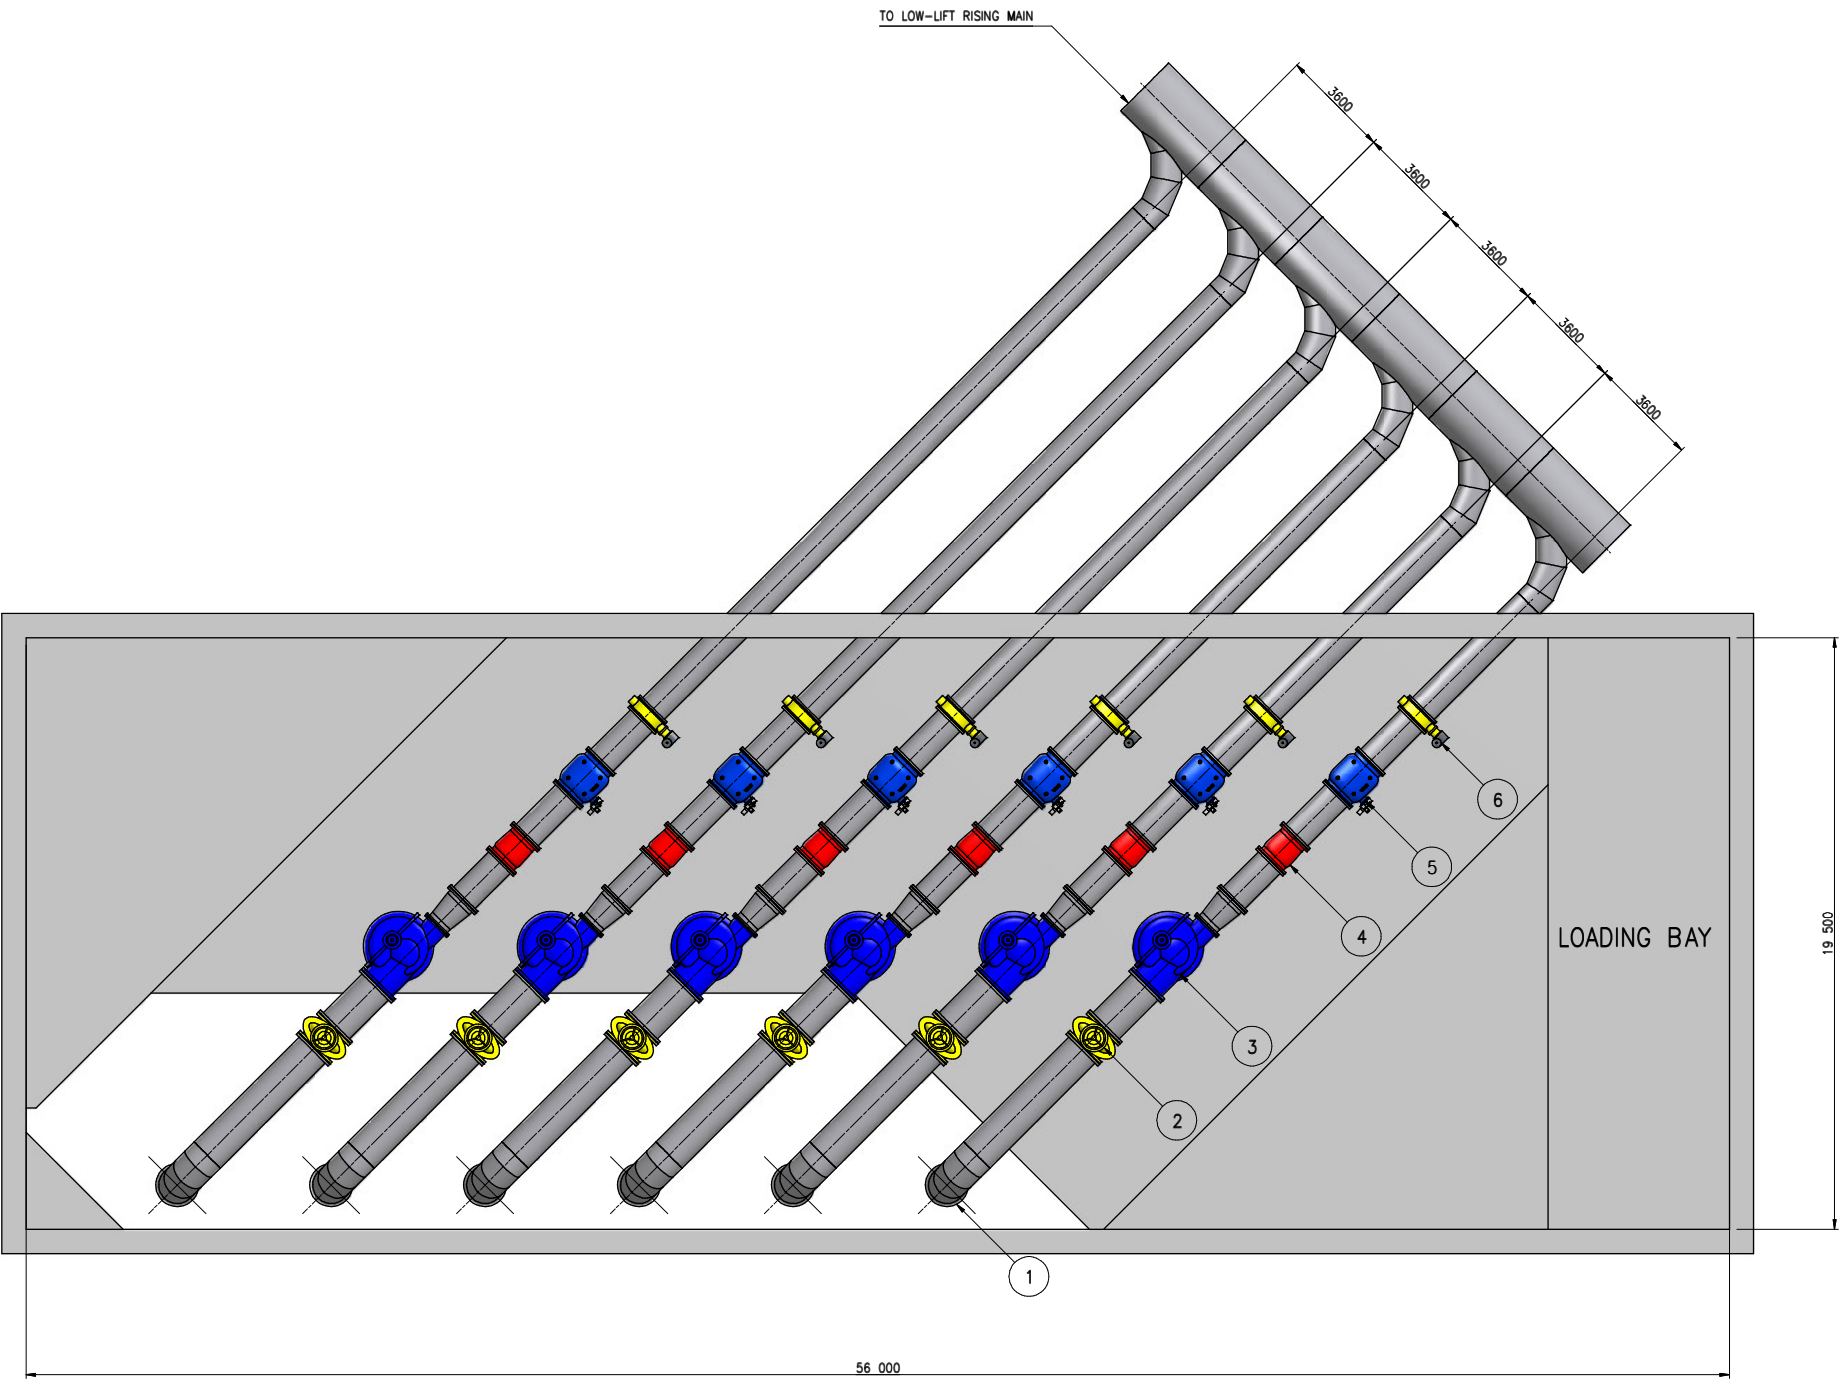

LOW-LIFT PUMP STATION LAYOUT
SCALE 1 : 250

PARTS LIST		
ITEM	QTY	DESCRIPTION
1	6	BELLMOUTH INTAKE
2	6	DN1200 PN16 WEDGE GATE VALVE
3	6	LOW-LIFT PUMP (VERTICAL MOTOR MOUNT)
4	6	DN1000 PN16 NOZZLE CHECK VALVE
5	6	DN1000 PN16 CONTROL VALVE
6	6	DN1000 PN16 BUTTERFLY VALVE

 REFERENCE DRAWINGS		REVISIONS				DESIGNED:	D VAN COLLER	PROJECT ENGINEER:	P LE ROUX		MOKOLO CROCODILE WATER AUGMENTATION PROJECT (MCWAP)				
DRG. No.	TITLE	REV No.	DATE	DESCRIPTION	APPR.	DRAWN:	D VAN COLLER	TCTA:			VLIEEPOORT ABSTRACTION WORKS				
		A	28/01/11	FOR INFORMATION	PLR	CHECKED:	J MULDER				LOW-LIFT PUMP STATION				
						CHIEF DESIGNER:		SCALE:	1:250		LAYOUT AND MECHANICAL DETAILS				
						SCALE 1 : 250 					A3	DWAF	DRAWING	REV No.	
												DRG. No.	NUMBER	2B-C5-006	A

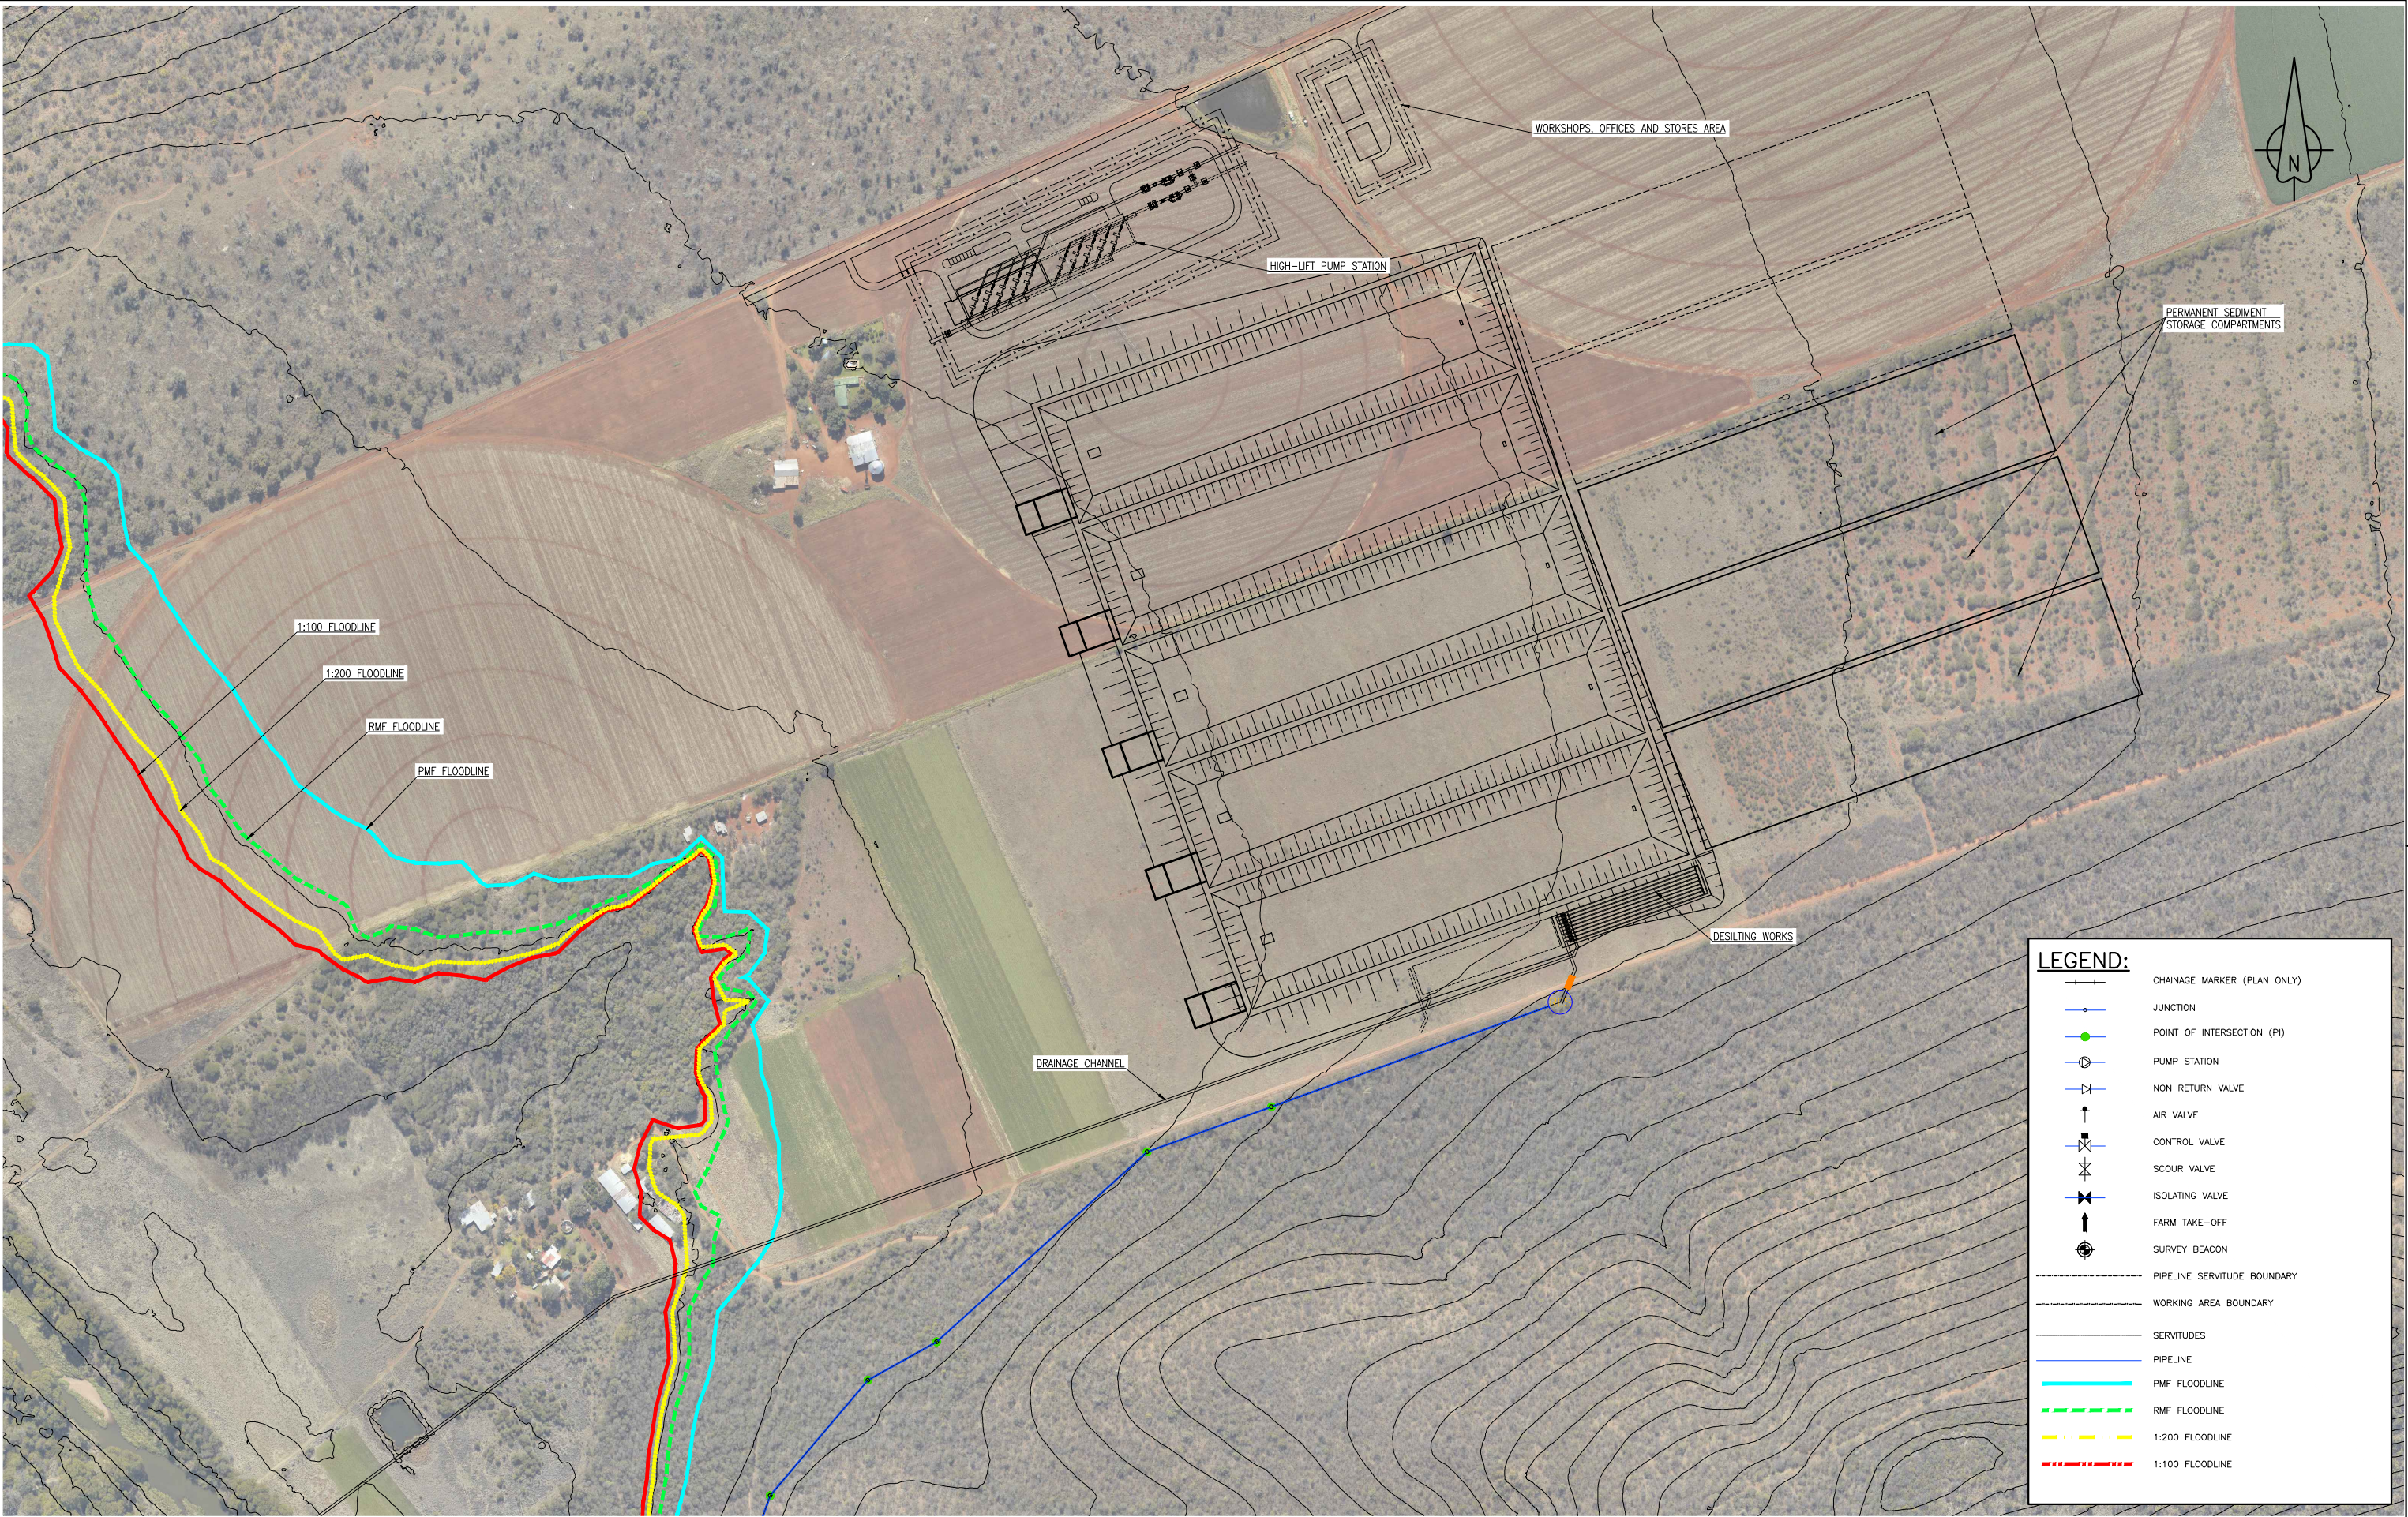

LEGEND:

CHAINAGE MARKER (PLAN ONLY)

JUNCTION

POINT OF INTERSECTION (PI)

PUMP STATION

NON RETURN VALVE

AIR VALVE

CONTROL VALVE

SCOUR VALVE

ISOLATING VALVE

FARM TAKE-OFF

SURVEY BEACON

PIPELINE SERVITUDE BOUNDARY

WORKING AREA BOUNDARY

SERVITUDES

PIPELINE

PMF FLOODLINE

RMF FLOODLINE

1:200 FLOODLINE

1:100 FLOODLINE


REFERENCE DRAWINGS		REVISIONS				DESIGNED:	D VAN COLLER	PROJECT ENGINEER:	P LE ROUX		MOKOLO CROCODILE WATER AUGMENTATION PROJECT (MCWAP)				
DRG. No.	TITLE	REV No.	DATE	DESCRIPTION	APPR.	DRAWN:	D VAN COLLER	TCTA:			VLIEEPOORT ABSTRACTION WORKS				
		A	11/03/11	FOR INFORMATION	PLR	CHECKED:	J MULDER				BALANCING DAM AND HIGH-LIFT PUMP STATION				
		B	21/11/17	ADD WORKSHOP, OFFICES AND STORES FOOTPRINT	PLR	CHIEF DESIGNER:	E SERFONTEIN	SCALE:	1:5000		GENERAL LAYOUT				
						SCALE: 1:5000 					A3	DWAF DRG. No.	DRAWING NUMBER	2B - C3 - 002	REV No. B

BREAK PRESSURE RESERVOIR DETAILS	
DESCRIPTION	VALUE
NON SPILL OVER CREST	1105.00 mASL
BASE LEVEL	1097.96 mASL
	1100.00 mASL
EMBANKMENT HEIGHT	6.34 m (MAXIMUM)
	1.62 m (MINIMUM)
SLOPES	SIDE SLOPES 1 : 2
	FLOOR 1 : 100
COMPARTMENT VOLUME	50 000 m³
WATER LEVEL	1104.00 mASL
FREE BOARD	1 m
WATER DEPTH	6.04 m (MAXIMUM)
	5.00 m (MINIMUM)
SPILLWAY DEPTH	0.6 m
SPILLWAY WIDTH	12 m




REFERENCE DRAWINGS		REVISIONS				DESIGNED:	N JORDAAN	PROJECT ENGINEER:	P LE ROUX	MOKOLO CROCODILE Consultants  TCTA A new word for water	MOKOLO CROCODILE WATER AUGMENTATION PROJECT (MCWAP)			
DRG. No.	TITLE	REV No.	DATE	DESCRIPTION	APPR.	DRAWN:	N JORDAAN	TCTA:			BREAK PRESSURE RESERVOIR			
		A	15/12/10	FOR INFORMATION	PLR	CHECKED:	J MULDER				GENERAL LAYOUT			
						CHIEF DESIGNER:	E SERFONTEIN	SCALE:	AS SHOWN					
						SCALE 1 : 2000								
										A3	DWAF DRG. No.	DRAWING NUMBER	2D - C3 - 001	REV No. A

OPERATIONAL RESERVOIR DETAILS	
DESCRIPTION	VALUE
NON SPILL OVER CREST	1019.00 mASL
BASE LEVEL	1011.00 mASL
	1012.55 mASL
EMBANKMENT HEIGHT	5.49 m (MAXIMUM)
	2.95 m (MINIMUM)
SLOPES	SIDE SLOPES 1 : 2
	FLOOR 1 : 100
COMPARTMENT VOLUME	50 000 m³
WATER LEVEL	1018.00 mASL
FREE BOARD	1 m
WATER DEPTH	7 m (MAXIMUM)
	5.45 m (MINIMUM)
SPILLWAY DEPTH	0.6 m
SPILLWAY WIDTH	12 m

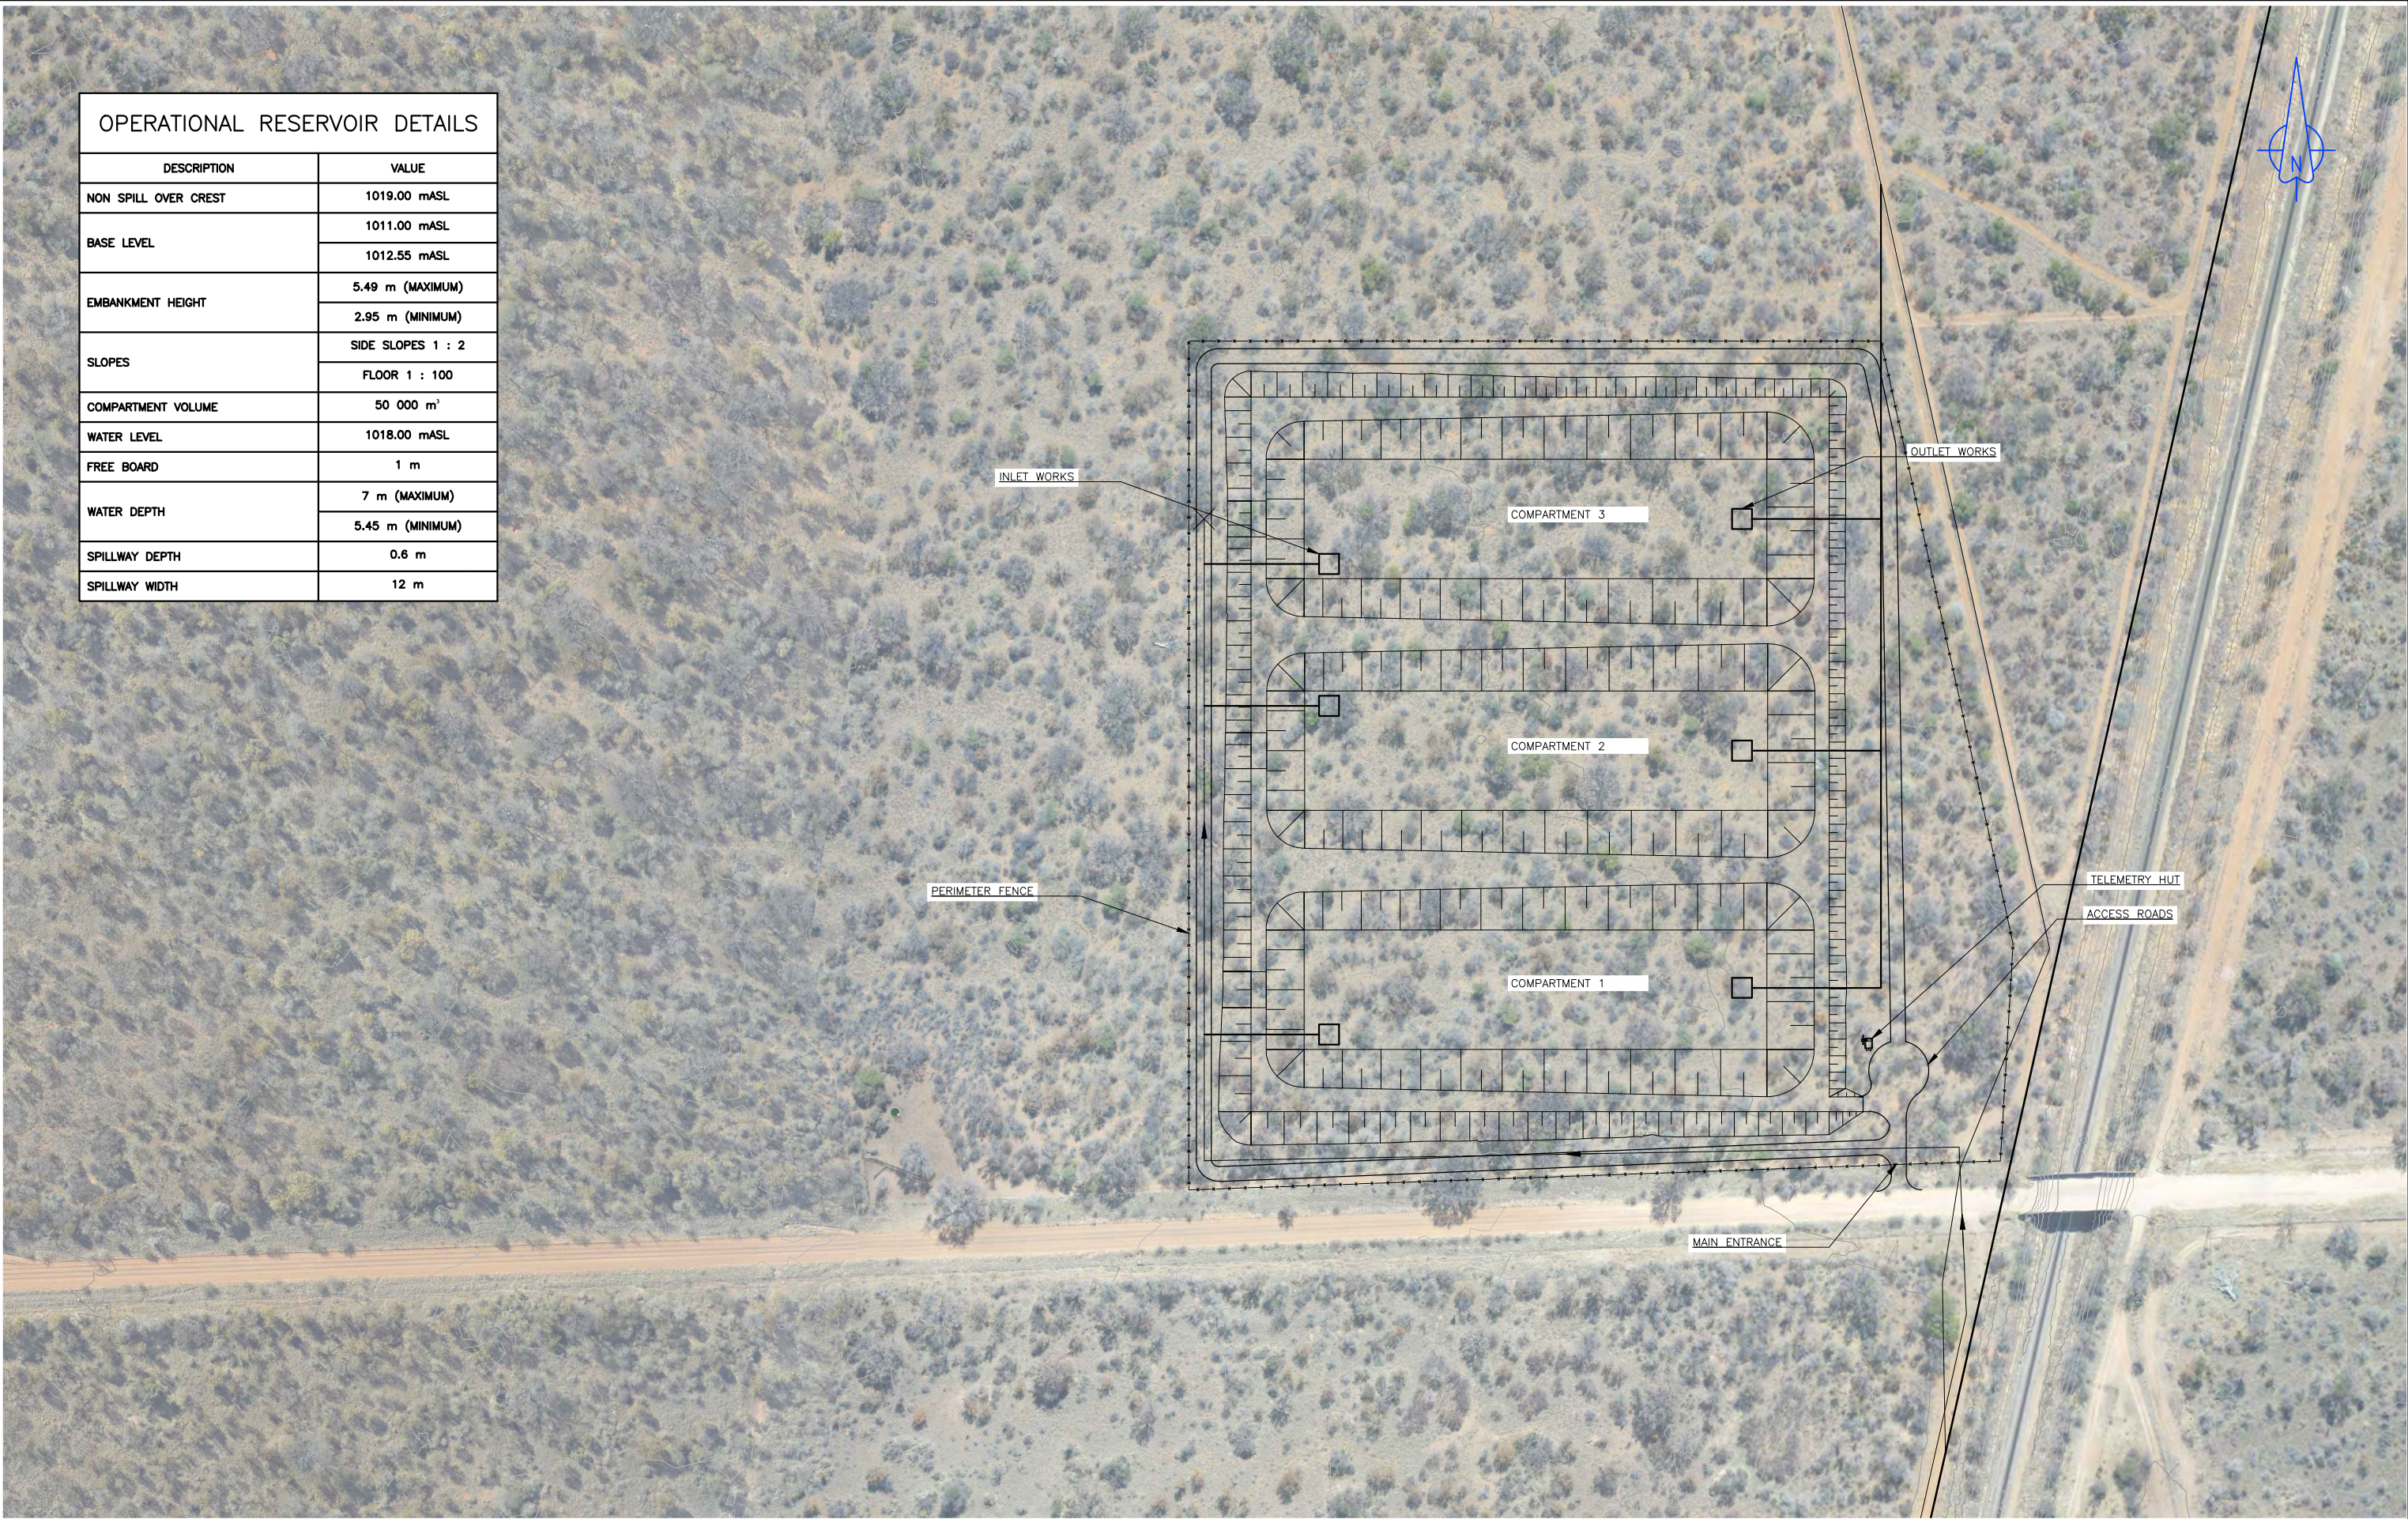


REFERENCE DRAWINGS		REVISIONS				DESIGNED:	J MULDER	PROJECT ENGINEER:	P LE ROUX			MOKOLO CROCODILE WATER AUGMENTATION PROJECT (MCWAP)									
DRG. No.	TITLE	REV No.	DATE	DESCRIPTION	APPR.	DRAWN:	J MULDER	TCTA:													
		A	07/12/10	FOR INFORMATION	PLR	CHECKED:	E SERFONTEIN					OPERATIONAL RESERVOIR GENERAL LAYOUT									
						CHIEF DESIGNER:	E SERFONTEIN	SCALE:	AS SHOWN												
						SCALE 1 : 2000						A3		DWAF DRG. No.		DRAWING NUMBER		2D - C3 - 010		REV No. A	

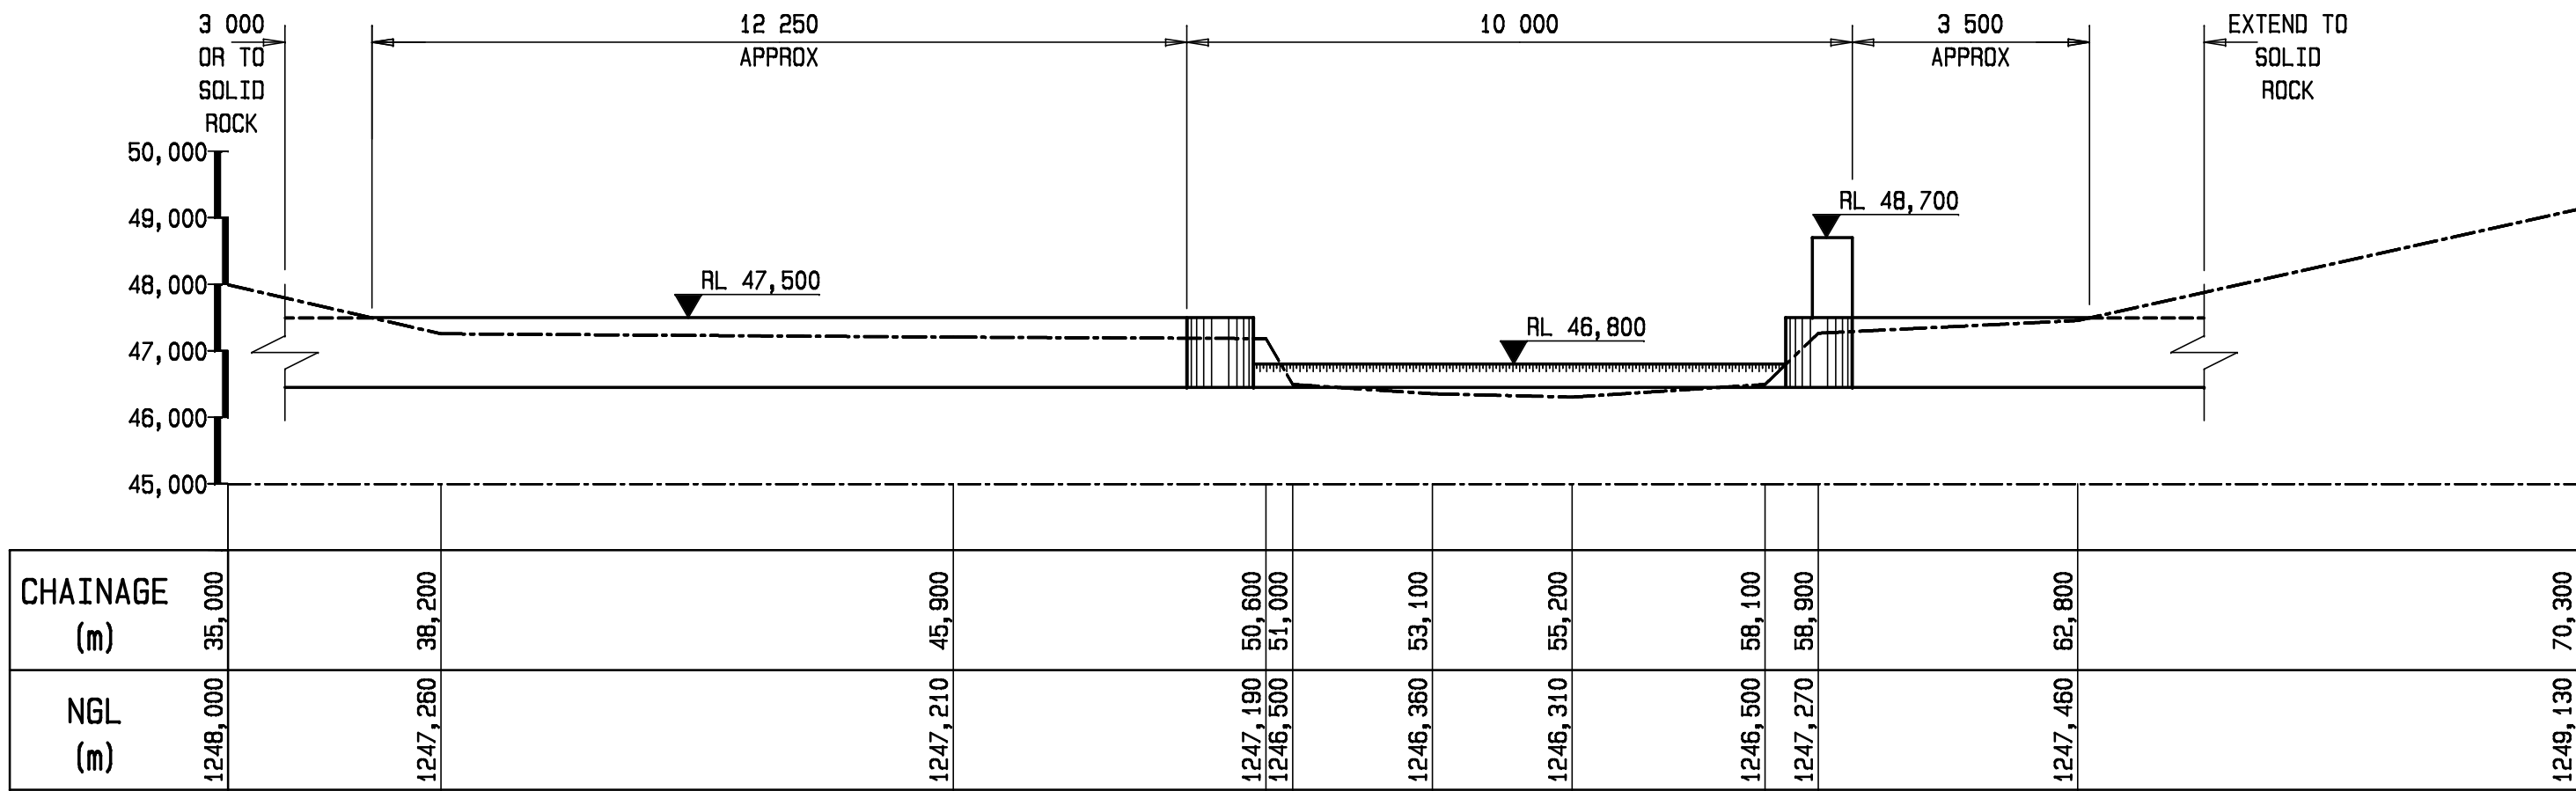

UPSTREAM ELEVATION


SCALE 1:100

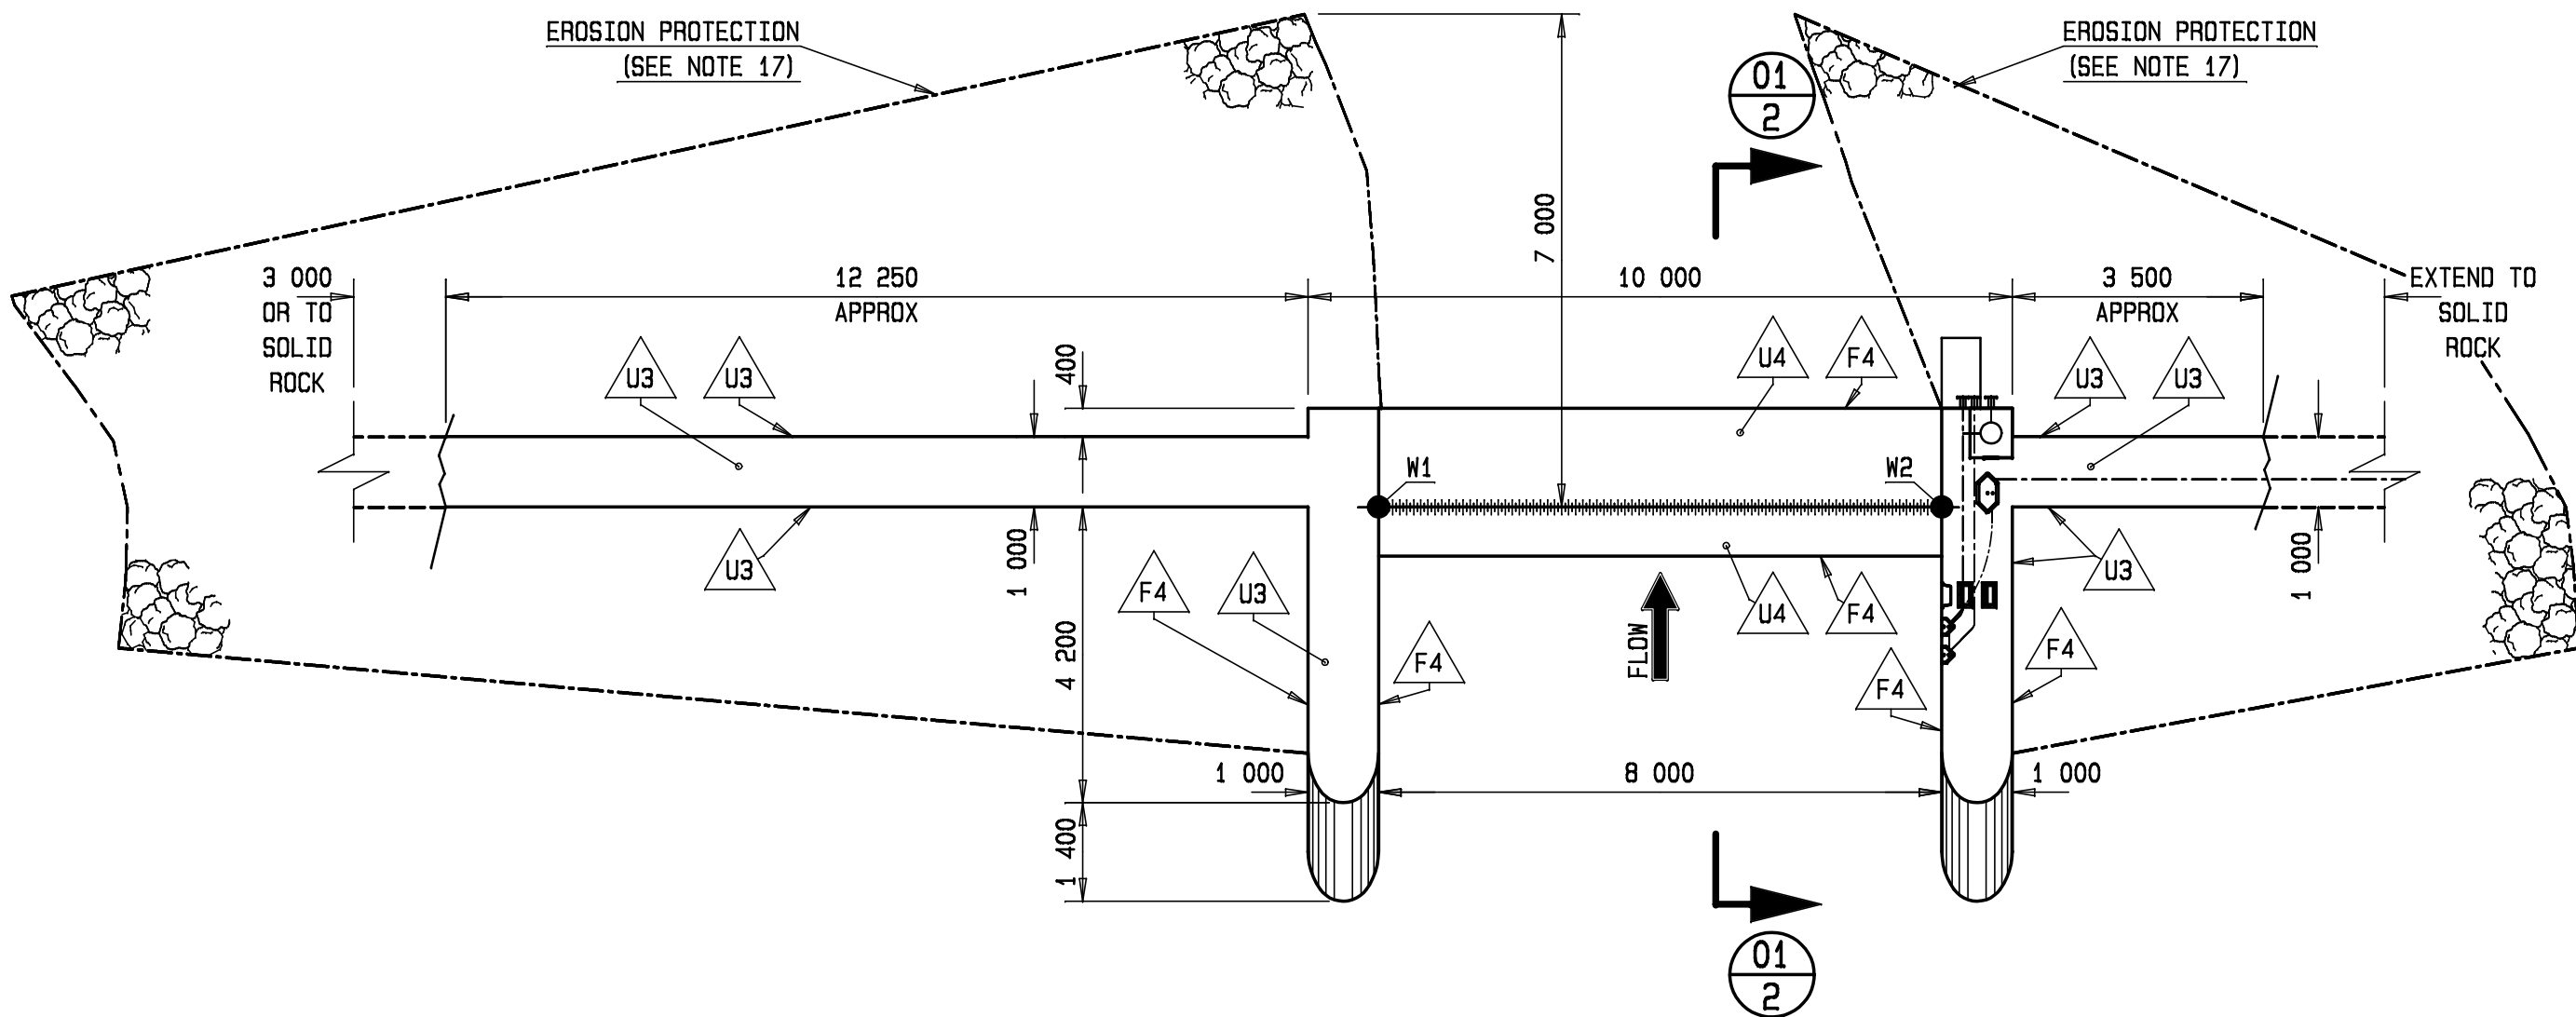

PLAN

SCALE 1:100


CONCRETE TOLERANCE			
SURFACE IRREGULARITIES			
CLASS OF FINISH	TOLERANCES IN mm		
	A	B	
CAST AGAINST FORMWORK	F1	10	20
	F2	5	10
	F3	2	7
	F4	NIL	5
NOT CAST AGAINST FORMWORK	U1	10	20
	U2	NIL	10
	U3	NIL	7
	U4	NIL	5
A IS THE MAXIMUM ALLOWABLE ABRUPT IRREGULARITY B IS THE MAXIMUM ALLOWABLE GRADUAL IRREGULARITY			

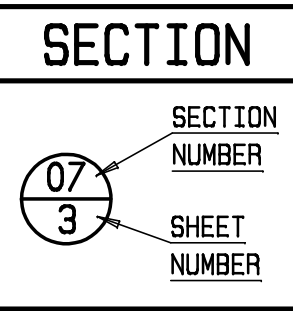

CO-ORD SYSTEM: L031 HARTEBEESHOEK			
RL FROM DMS9: 1 198,14 m ABOVE MSL			
BMS5	1198,18	88 270,92	3 256 088,95
STATION		RL	Y
DW1	1248,21	90 965,79	3 253 051,11
DW2	1251,90	91 011,39	3 253 048,30
DW3	1248,08	90 965,87	3 253 012,87
STRUCTURE		RL	Y
W1	1246,80	90 971,68	3 253 030,34
W2	1246,80	90 976,43	3 253 036,78
SERVITUDE		Y	X
SEC4R	90 976,33	3 253 050,30	
SEC7R	90 999,18	3 253 049,92	
S1	90 987,65	3 253 037,71	
S2	91 008,31	3 253 004,97	
S3	91 001,81	3 252 999,01	
DW03	90 965,87	3 253 012,87	
S4	90 959,18	3 253 008,22	
S5	90 951,37	3 253 015,79	

NOTES:


- ANY DEVIATIONS FROM THE DESIGN DRAWINGS NEED TO BE APPROVED BY THE DESIGN ENGINEER PRIOR TO PLACING OF CONCRETE.
- NEW CONCRETE GRADE 25/19 (UNLESS SPECIFIED OTHERWISE).
- CAPACITY Q = 8,0 CUMecs, H = 0,635 m, SUBMERGENCE = 71%
- MINIMUM CONCRETE COVER = 70 mm (UNLESS SPECIFIED OTHERWISE).
- 15 x 15 mm CHAMFERS TO BE USED ON ALL EXPOSED CONCRETE CORNERS.
- ALL CONCRETE FINISHES SHALL BE AS FOLLOWS EXCEPT WHERE OTHERWISE SPECIFIED:
 - CLASSES F1 AND U1 TO SURFACES AGAINST WHICH BACKFILL OR FURTHER CONCRETE WILL BE PLACED
 - CLASSES F4 AND U4 FOR ALL SURFACES OVER OR AGAINST WHICH WATER WILL FLOW
 - UNFORMED SURFACE PREPERATION AND FINISH (ON WEIR CRESTS):
 - FIRST WOOD FLOAT
 - STEEL FLOAT WHILST PRESSING HARD (AFTER BLEEDING WATER HAS EVAPORATED UNTILL SMOOTH FINISH HAS BEEN ACHIEVED
 - APPLY STEEL TROWEL SURFACE FINISH
 - MOIST CURE FOR 10 DAYS WITHOUT USE OF ANY CURING AGENTS
 - APPLY VERNIT RADCON FORMULA #7 OR EQUIVALENT OVER ALL THE NOTCHES AND SIDEWALLS OVER OR AGAINST WHICH WATER WILL FLOW
 - CLASSES F2 AND U2 TO SURFACES EXPOSED TO VIEW OVER OR AGAINST WHICH NO WATER FLOW WILL OCCUR (UNLESS SPECIFIED OTHERWISE)
 - TOLERANCES FOR ALL FINISHES ARE INDICATED IN CONCRETE TOLERANCE TABLE
- ALL VERTICAL DOWELS SHALL BE GROUTED WITH A SHRINKAGE COMPENSATED CEMENTITIOUS GROUT 0,4:1 W/C RATIO (BY MASS) OR BASF-SUPERFLOW BEDDING GROUT OR EQUIVALENT.
- WET TO DRY EPOXY TO BE APPLIED ON ALL OLD EXISTING CONCRETE SURFACES BEFORE PLACEMENT OF NEW CONCRETE (ACCORDING TO MANUFACTURER'S SPECIFICATIONS). ALL SEALANTS USED AT CONSTRUCTION JOINTS TO BE APPLIED ACCORDING TO MANUFACTURER'S SPECIFICATIONS.
- THE FOLLOWING TOPICS WILL BE DECIDED ON SITE IN CONSULTATION WITH THE DESIGN ENGINEERS:
 - ROUTE OF ACCESS ROAD.
 - EXTENT AND EXACT LAYOUT OF CUT-OFF WALLS.
 - FINAL POSITION OF THE RECORDER HUT.
 - EXTENT OF EROSION PROTECTION OF THE EMBANKMENTS.
- CONDUIT PIPES (90 mm NOM. Ø HOPE 80 PN 6 PIPE) TO BE LAID WITH 6 mm SKI ROPE INSIDE FOR LATER INSTALLATION OF DATA CABLES. CONDUIT PIPES MAY ONLY BE JOINED USING A DRAW BOX. MAXIMUM DISTANCE ALLOWED BETWEEN DRAW BOXES IS 35m. DRAW BOXES SHOULD BE INSTALLED AT ANY 90° CHANGE IN CONDUIT PIPE DIRECTION.
- INSTRUMENTATION (EG. GAUGE PLATES, SOLAR PANEL, LOGGER AND PRESSURE PROBES ETC.) SHOULD COMPLY WITH STANDARDS SET BY HYDROLOGICAL SERVICES. PRESSURE PROBES, LOGGERS AND SOLAR PANELS TO BE INSTALLED BY HYDROLOGY REGIONAL STAFF. ALL CONDUIT PIPE OPENINGS TO BE SEALED OFF AFTER INSTALLATION OF INSTRUMENTATION.
- INSTRUMENTATION- AND DRAW BOXES, FLUSH STEPS AND SECURITY DOORS WITH ALL REQUIRED PARTS AND CONNECTIONS OBTAINABLE FROM INTERLOCK SYSTEMS (AS PER CONTRACT # 9257). CONTACT TEL NUMBER: (012) 664-2647.
- PERMANENT BENCH MARKS TO BE INSTALLED ON LEFT AND RIGHT BANK CUT-OFF WALLS.
- ROCK SURFACE, DIRECTLY RECEIVING CONCRETE, SHALL BE PROPERLY CLEANED AND PREPARED PRIOR TO CONCRETE CASTING. ALL ORGANIC MATERIAL AND LOOSE STONES MUST BE REMOVED. ALL FOUNDATIONS AND FOUNDATION PREPERATION NEED TO BE APPROVED BY THE DESIGN ENGINEER OR ON-SITE DESIGN REPRESENTATIVE BEFORE PLACEMENT OF CONCRETE.
- DETAIL OF PROPOSED RIVER DIVERSION NEED TO BE SUBMITTED FOR EVALUATION AND APPROVAL TO THE DESIGN ENGINEER OR ON-SITE DESIGN REPRESENTATIVE BEFORE COMMENCEMENT OF DIVERSION WORKS.
- TOLERANCE ON STAINLESS STEEL ANGLE ON CRUMP CREST TO BE +/- 0 mm TO 1 mm.
- EXTENT OF EROSION PROTECTION TO BE FINALISED ON SITE IN CONSULTATION WITH DESIGN ENGINEER.
- SEE ALSO ADDITIONAL NOTES ON OTHER SHEETS WHERE APPLICABLE.

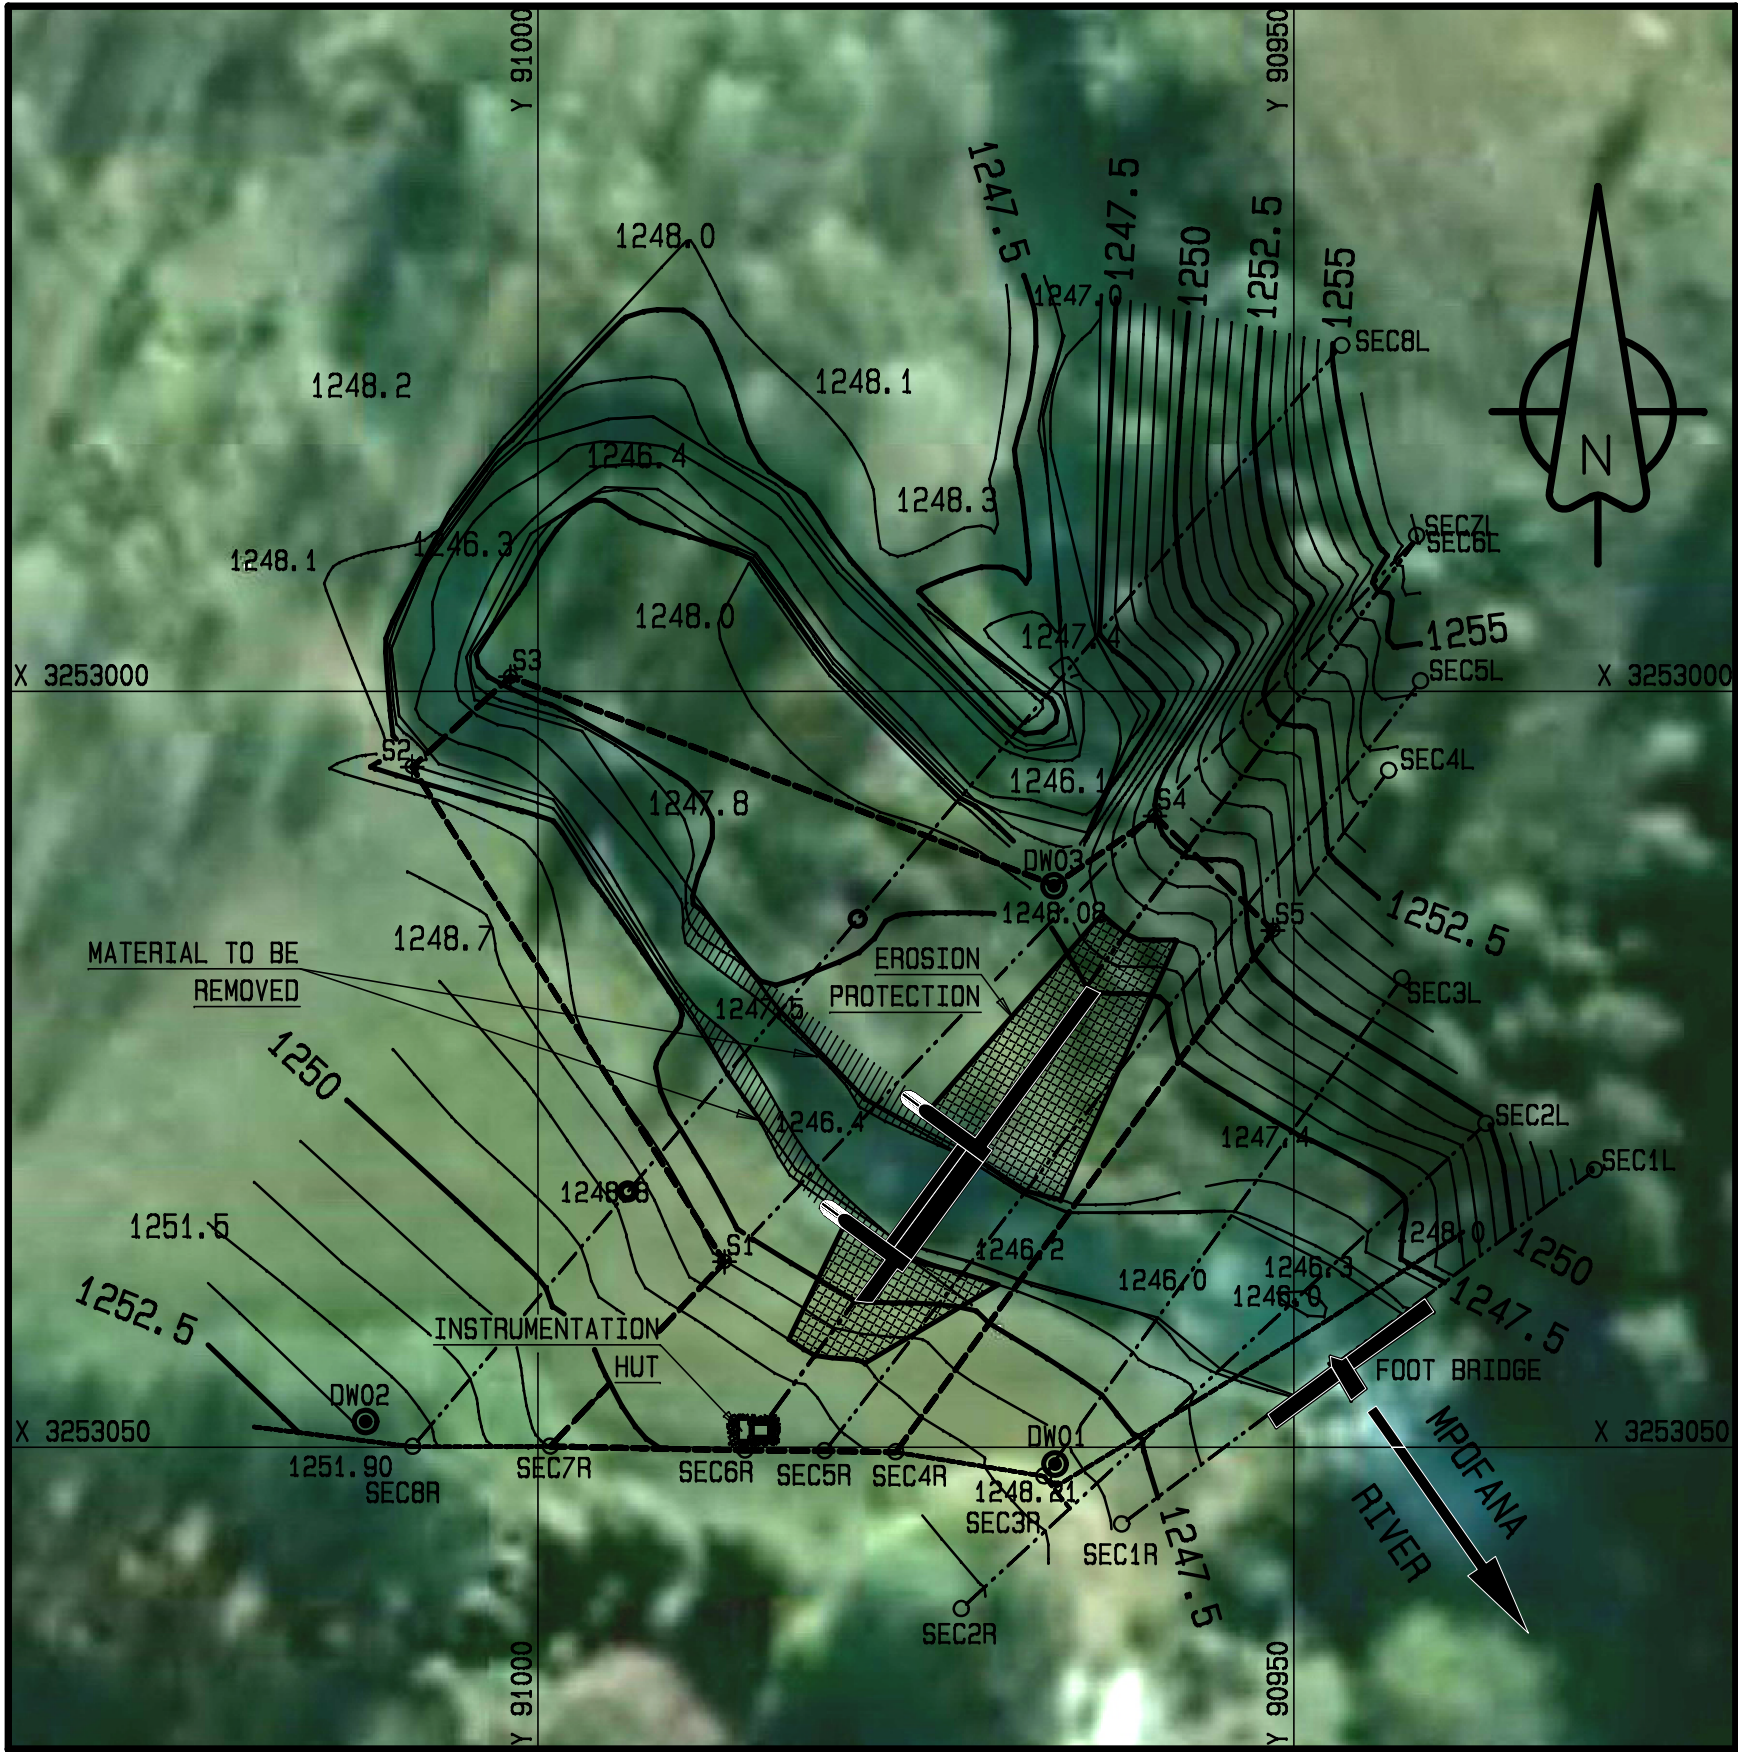


LOCALITY PLAN

SCALE 1:500

 SCALE 1:100



SCALE 1:500

 


REVISION			
MOD No.	DATE	DESCRIPTION	DWA


DEPARTMENT OF WATER AFFAIRS AND FORESTRY REPUBLIC OF SOUTH AFRICA			
HEAD OFFICE CIVIL ENGINEERING PRIVATE BAG X313 PRETORIA 0001		SEDIBENG BUILDING 185 SCHODMAN STREET PRETORIA (012) 336-7500	
P. YAKO DIRECTOR GENERAL		DESIGN: P. WESSELS	
CHECKED:		DATE: DRAWN: A.A. VAN DER WALT	
ENGINEER:		DATE: EXTERNAL APPROVAL: DATE:	
CHIEF ENGINEER / APP (Pr. Eng):		DATE: ACTING DIRECTOR (Pr. Eng): DATE:	

HYDROLOGICAL SERVICES			
MPOFANA RIVER GAUGING WEIR (SPRING GROVE DAM) PLAN, DETAIL AND LOCALITY			
PROVINCE: -	DISTRICT: -	KEYCODES: HYD W66 - - - -	OTHER NUMBER -
LOCALITY No.1: -	TENDER/ CONTRACT No. -	SHEET REG. No.	REV.
CALCULATION FILE: -		1 OF 4	157 477/09 -


4/4	INSTRUMENTATION HUT	X	157 480/09
3/4	INSTRUMENTATION	X	157 479/09
2/4	SECTIONS AND DETAIL	X	157 478/09
1/4	PLAN, DETAIL AND LOCALITY	X	157 477/09
SHEET	DESCRIPTION	OTHER No.	REG. No.
LIST OF DRAWINGS			

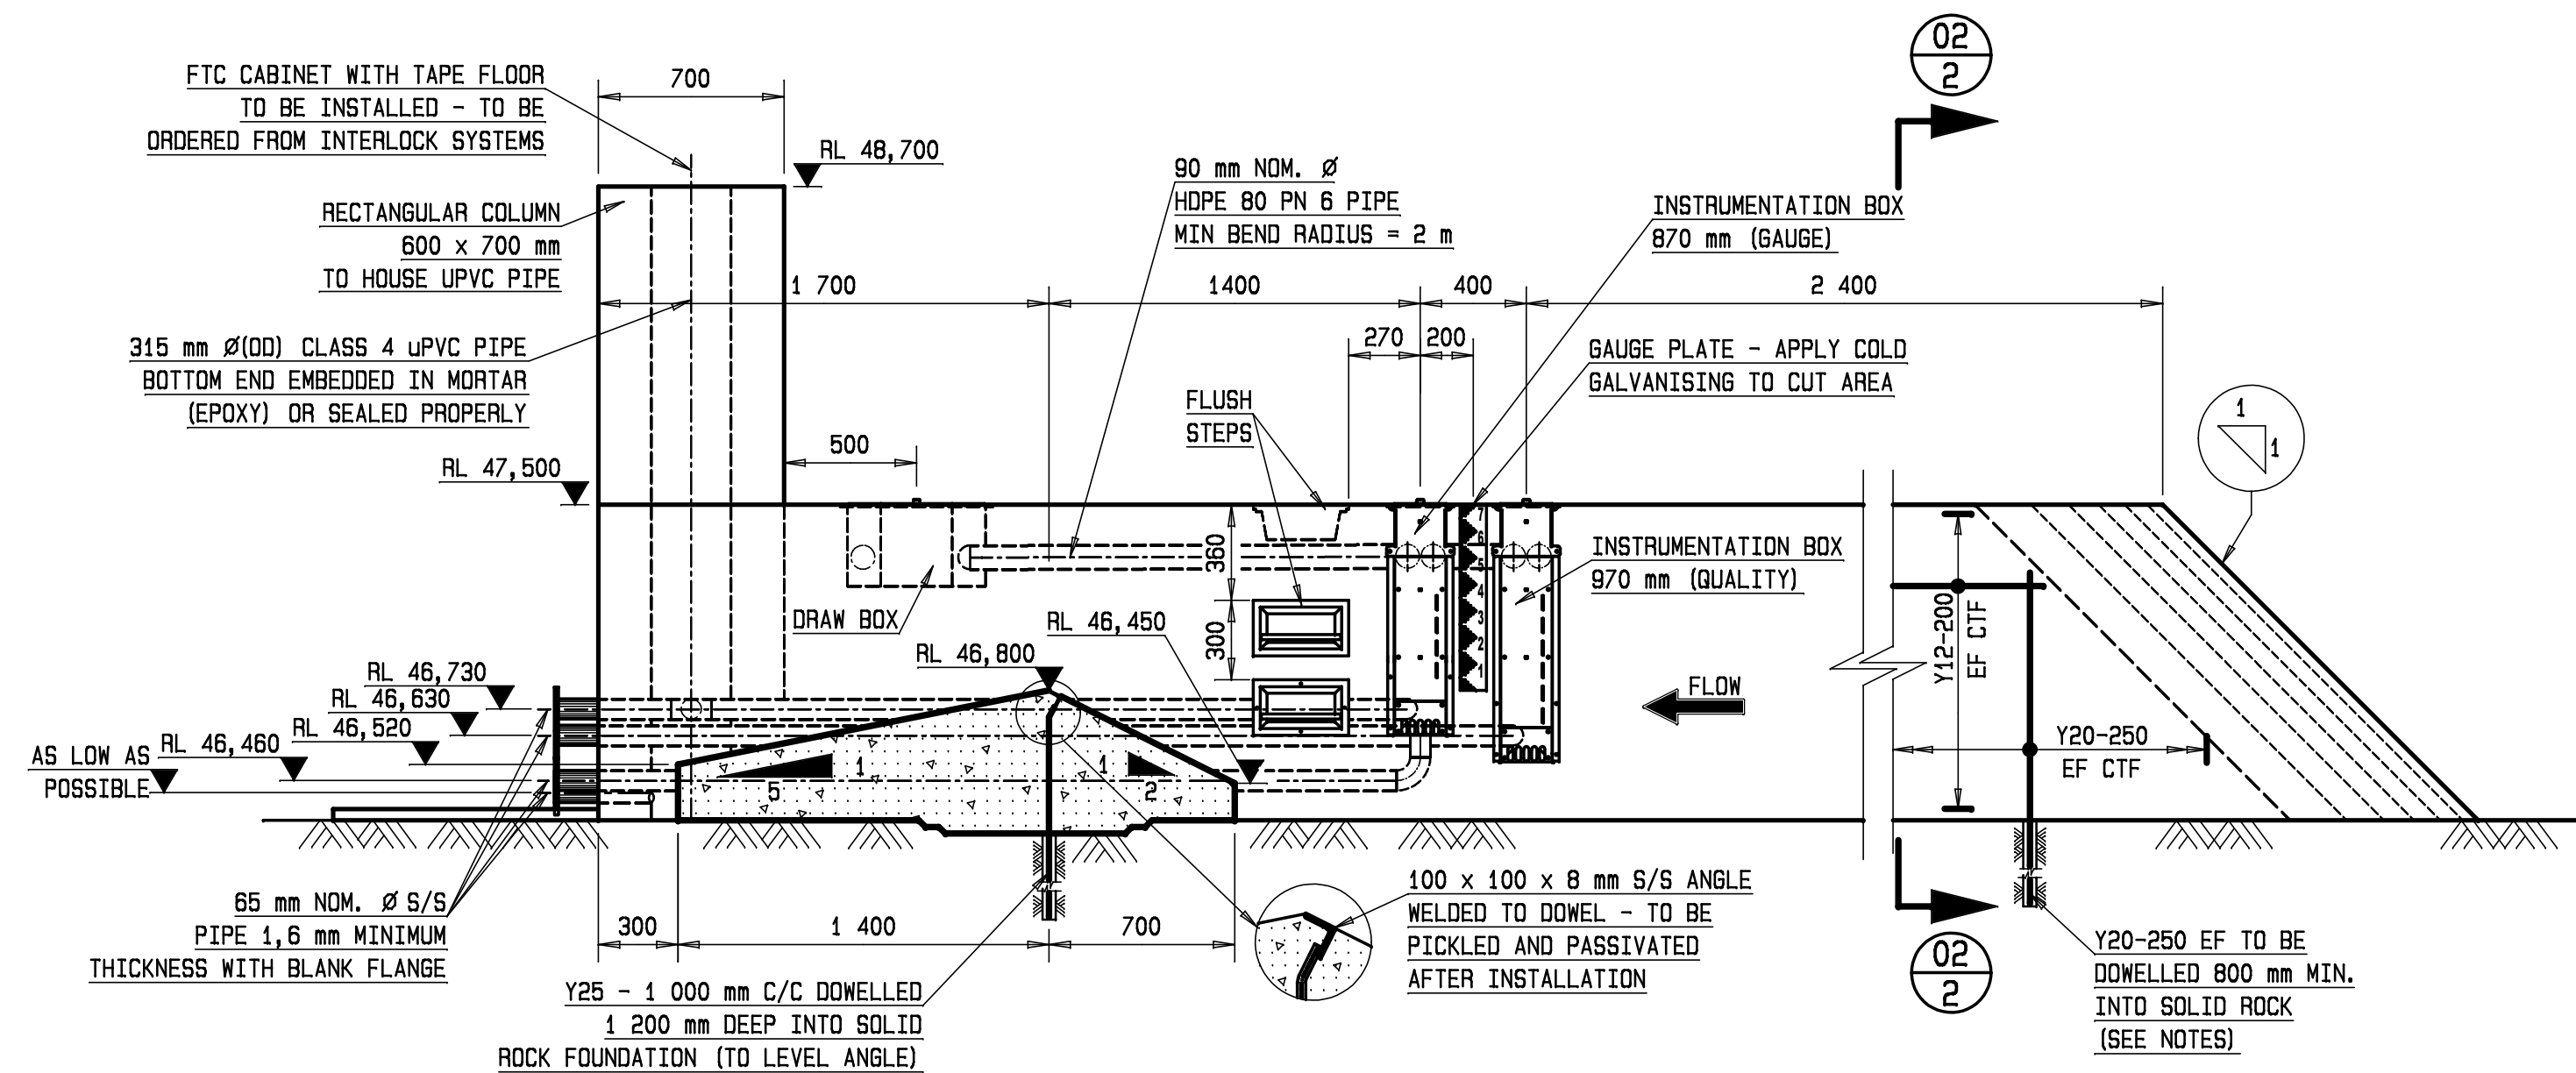


SECTION 01-01
SCALE 1:25

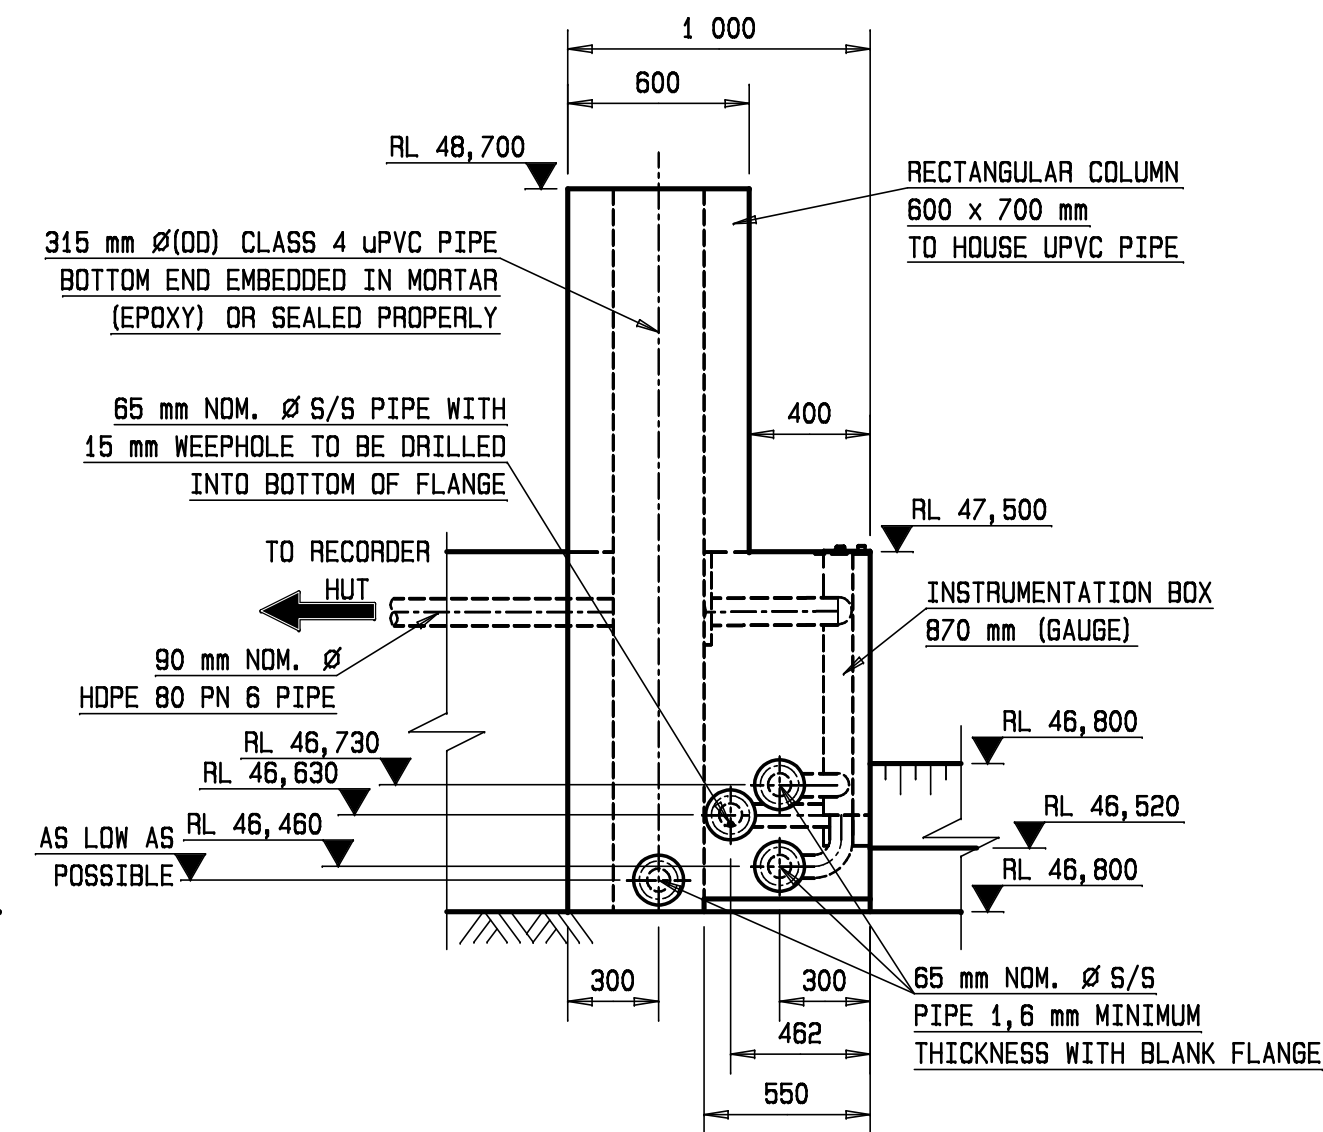


D/S ELEVATION (SECTION 01-01)
SCALE 1:25

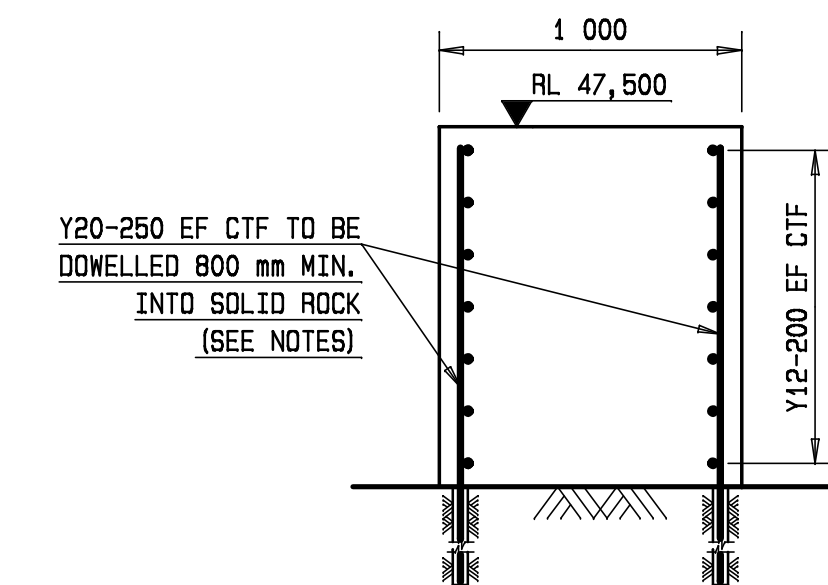

SECTION 02-02
SCALE 1:25

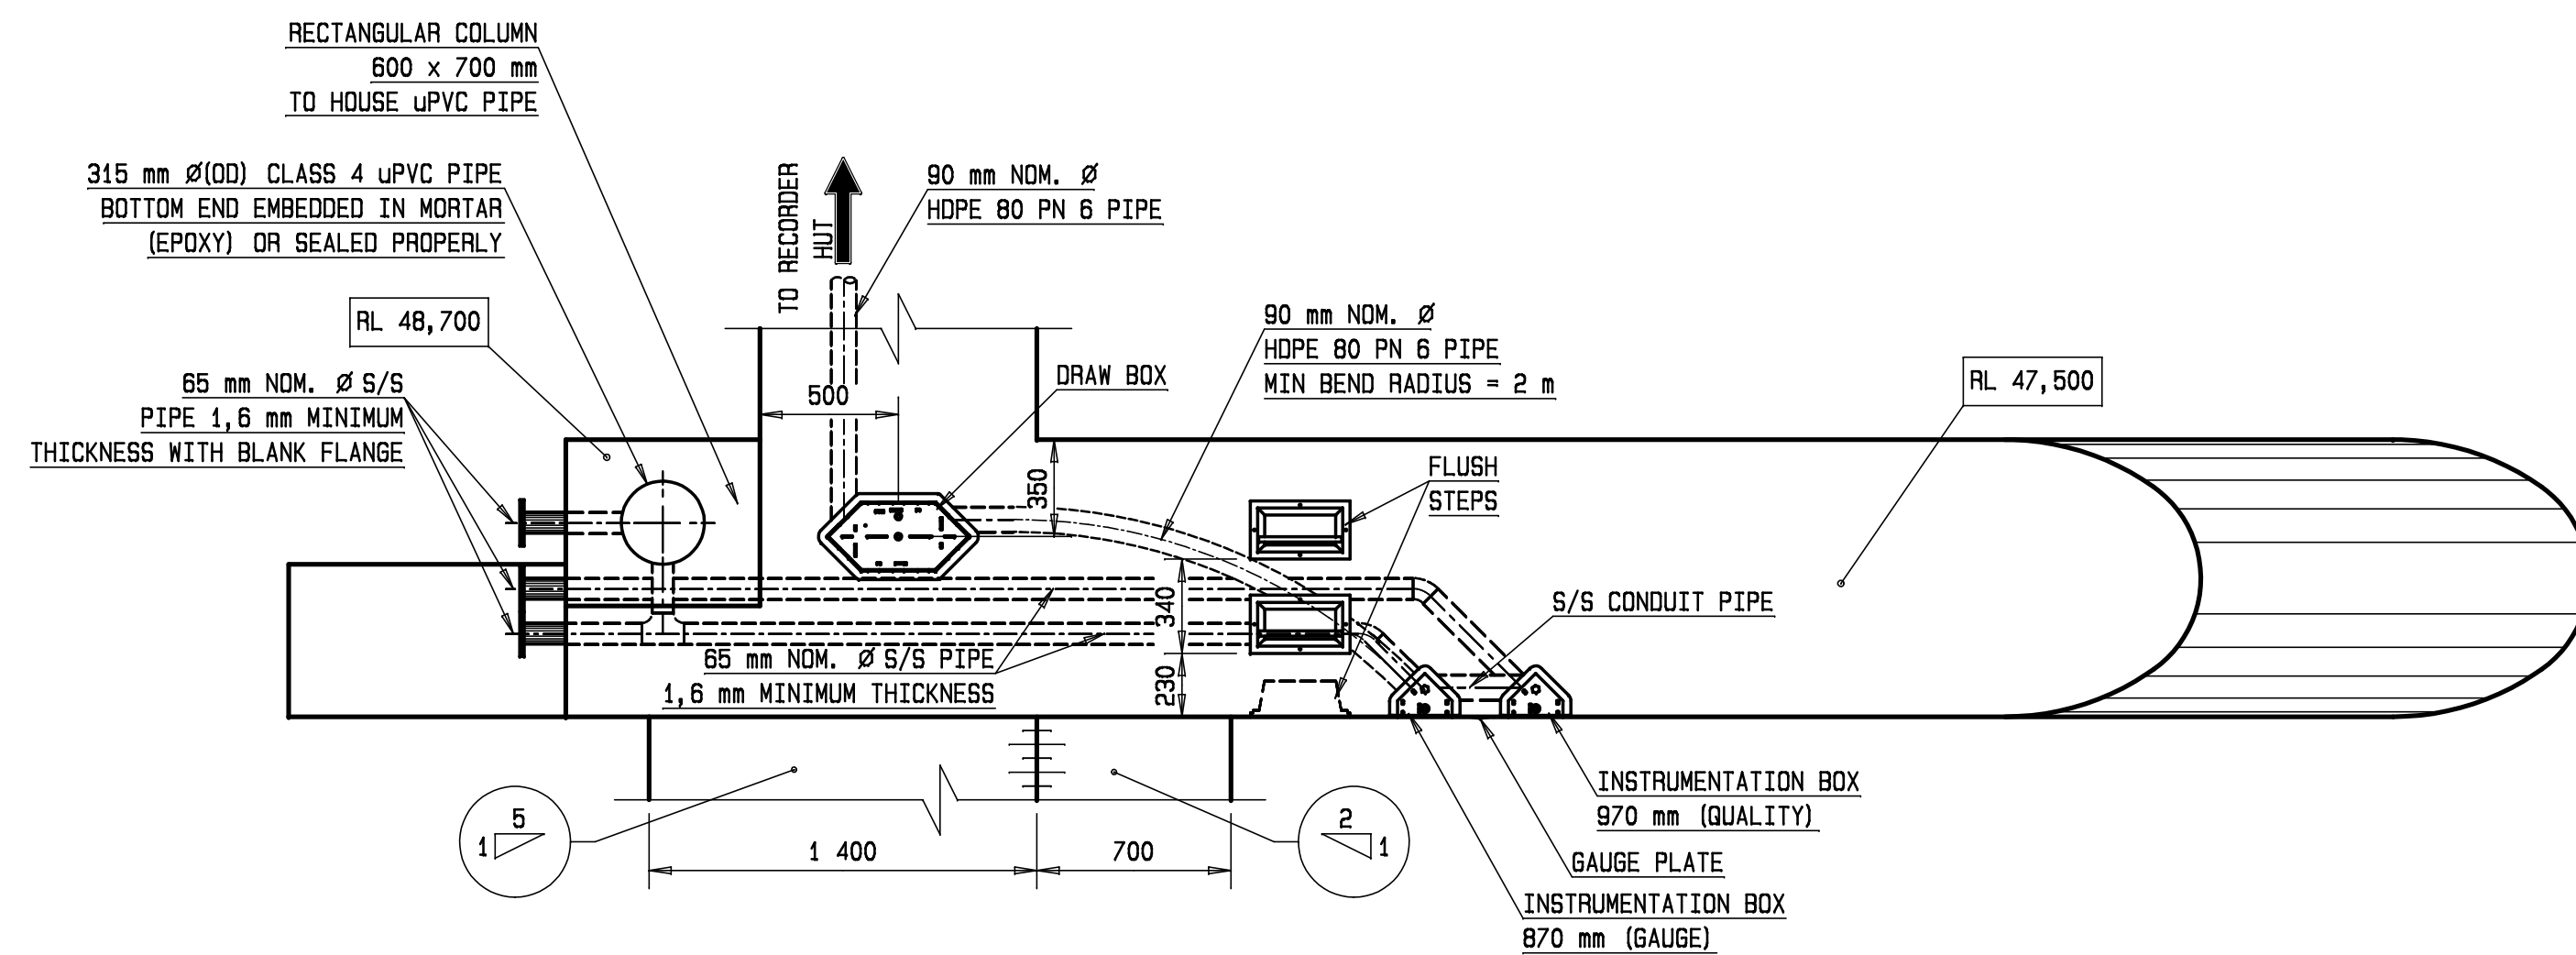


PLAN (SECTION 01-01)
SCALE 1:25

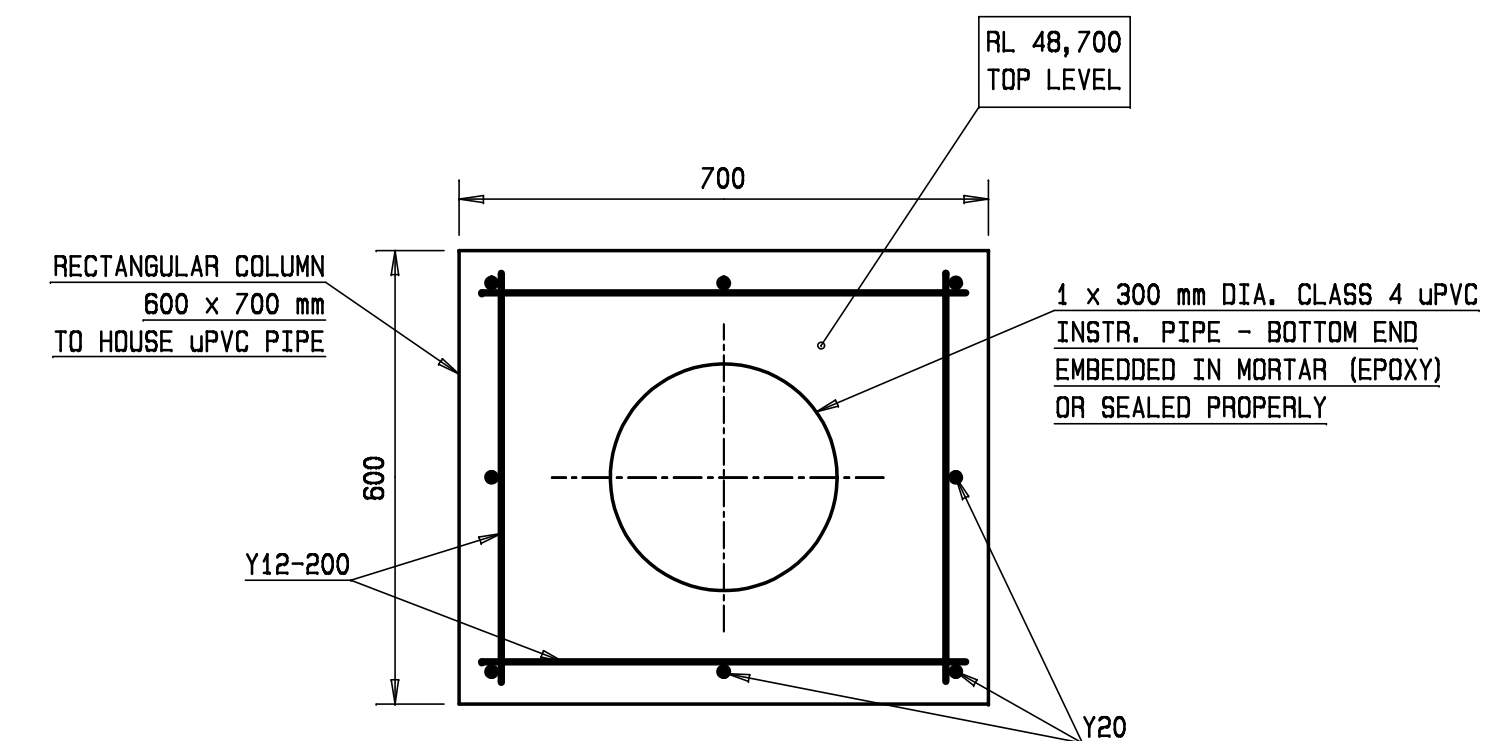


WET WELL REINFORCEMENT
SCALE 1:10

4/4	INSTRUMENTATION HUT	X	157 480/09
3/4	INSTRUMENTATION	X	157 479/09
2/4	SECTIONS AND DETAIL	X	157 478/09
1/4	PLAN, DETAIL AND LOCALITY	X	157 477/09
SHEET	DESCRIPTION	OTHER No.	REV. No.
LIST OF DRAWINGS			

 SCALE 1:10



SCALE 1:25

 

REVISION			
MOD No.	DATE	DESCRIPTION	DNA

DEPARTMENT OF WATER AFFAIRS AND FORESTRY REPUBLIC OF SOUTH AFRICA			
HEAD OFFICE CIVIL ENGINEERING PRIVATE BAG X313 PRETORIA 0001		SEDIBENG BUILDING 185 SCHODMAN STREET PRETORIA (012) 336-7500	
P. YAKO DIRECTOR GENERAL		DESIGN: P. WESSELS	
CHECKED:		DATE: DRAWN: A.A. VAN DER WALT	
ENGINEER:		DATE: EXTERNAL APPROVAL:	
CHIEF ENGINEER / APP (Pr. Eng):		DATE: ACTING DIRECTOR (Pr. Eng):	

HYDROLOGICAL SERVICES			
MPOFANA RIVER GAUGING WEIR (SPRING GROVE DAM) SECTIONS AND DETAIL			
PROVINCE: -	DISTRICT: -	KEYCODES: HYD W66 - - -	OTHER NUMBER -
LOCALITY No.1 -	TENDER/ CONTRACT No. -	SHEET 2 OF 4	REV. 157 478/09 -
CALCULATION FILE: -			

Shape codes to S.A.S. 82, 1976 Tabel 5 (As amended 1978, 1984 and 1988)											
Preferred shapes										Other shapes	
20		39		62		72					
32		41		73							
33		42		74							
34		43		75							
126		135		167							